

RECORD PLANS

RESTON PONDS UNIT 3 SYCAMORE, ILLINOIS

DEVELOPER:

WISEMAN-HUGHES ENTERPRISES
975 EAST 22nd STREET
WHEATON, ILLINOIS 60187
(630) 653-0500

ENGINEER:

INTECH CONSULTANTS, INC.
5413 WALNUT AVENUE
DOWNERS GROVE, IL 60515
(630) 964-5656
ILLINOIS REGISTRATION No. 184-001040




CALL JULIE 1-800-892-0123

DEKALB

SYCAMORE

EI/2 4&5-40-5

48 HOURS BEFORE YOU DIG.

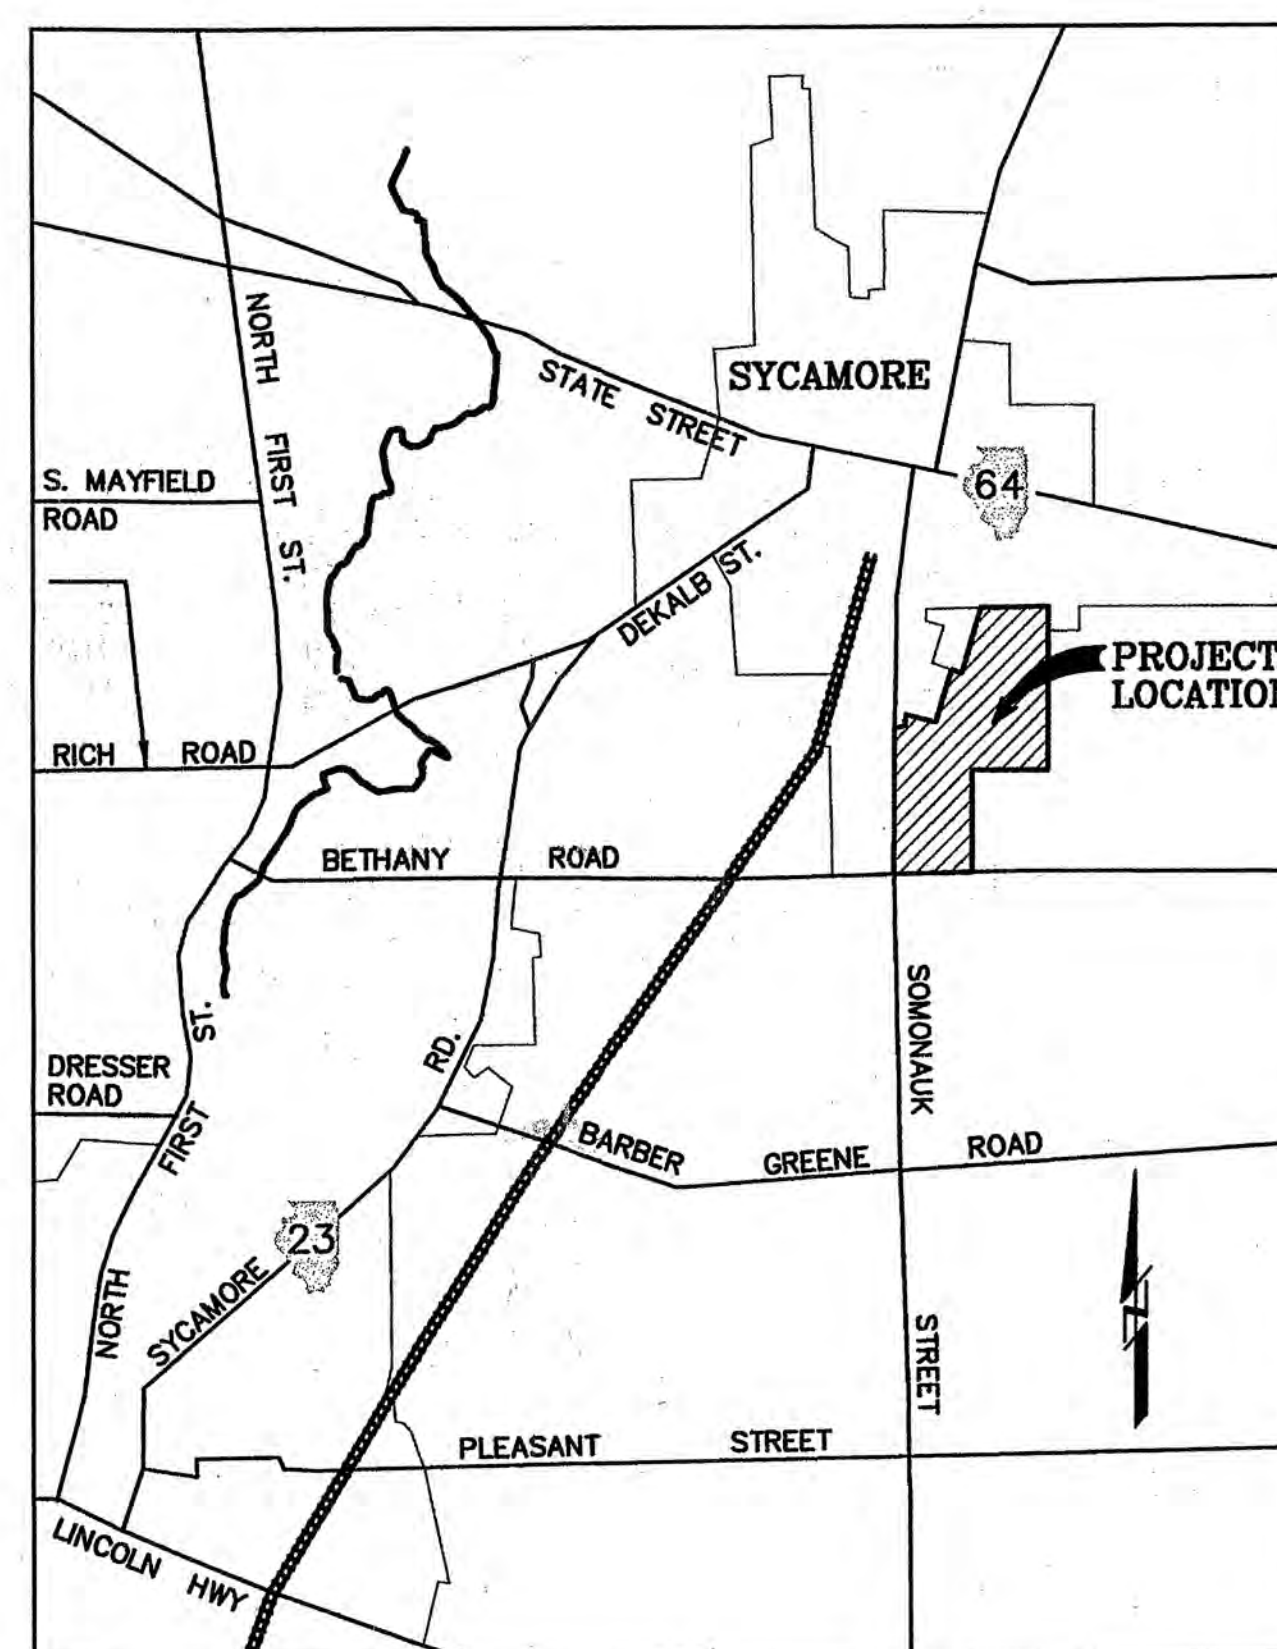

LOCATION MAP

N.T.S.

BENCHMARKS

1. TOP OF OPERATING NUT ON FIRE HYDRANT AT THE NORTHWEST CORNER OF SOMONAUK & PERRY COURT. ELEVATION = 871.38
2. NAIL IN POWER POLE AT NORTHWEST CORNER OF SOMONAUK STREET & BETHANY ROAD. ELEVATION = 877.30

INDEX

1. COVER SHEET
2. UTILITY PLAN
3. SOIL EROSION CONTROL PLAN
- 4-6. GRADING PLANS
- 7-16. PLAN & PROFILES
17. INTERSECTION DETAILS
- 18-19. SPECIFICATIONS
- 20-21. DETAILS
- 22-23. BOX CULVERT DETAILS
24. SIGNAGE PLAN

STATEMENT OF OPINION

I, John W. Stolberg, hereby state that in my professional opinion the specific PROJECT components shown as "Record" information on sheets 7-16, 19 and 22-23 have been completed in substantial conformance with the design intent of the approved Engineering Plans.

Dated this 27th day of April, 2007.

John W. Stolberg
Illinois Licensed Professional Engineer No. 062-044855

DATED AS OF 4-27-07


9/06/06	10	6HT. 4-6	JWS
8/22/06	9	6HT. 4-6	JWS
7/11/06	8	6HT. 6	JWS
06/30/06	7	4-6, 9 & 10	DKC
04/10/06	6	2, 11 & 13	DKC
02/02/06	5	2-17, 21, 23 & 24	DKC
12/30/05	4	2-17, 20-23	DKC
10/19/05	3	2, 3, 5, 11 & 13	DKC
09/19/05	2	2, 4-6, 8, 9, 12, 16, 17	DKC
05/16/05	1	2, 4-16, 20, 24	DKC
DATE	No.	SHEET REVISED	BY

PROJECT No.: 2001.029-3

DATE: 12/15/03

SHEET: 1 OF 24

DESIGN: JWS/WB DRAWN BY: DCK

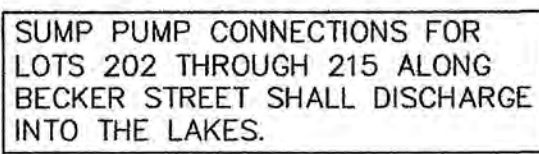

ALL ACTIVE FIELD TILES ENCOUNTERED AT THE PERIMETER OF THE PROJECT SHALL BE CONNECTED TO THE NEW STORM SEWER SYSTEM.

EXISTING	PROPOSED	
		SANITARY SEWER WITH MANHOLE CALLOUT FOR SANITARY MANHOLE
		SANITARY SERVICE RISER REQUIRED
		SANITARY SERVICE
		WATER MAIN & HYDRANT
		WATER SERVICE W/B-BOX
		VALVE IN VAULT W/LABEL
		VALVE & BOX W/LABEL
		FINISH GRADE AT HYDRANT/ VAULT RIM ELEV.
		STORM SEWER
		INLET, TYPE A
		CATCH BASIN, TYPE A
		2'x3' CATCH BASIN, SPECIAL
		MANHOLE, TYPE A WITH CLOSED LID
		MANHOLE, TYPE A WITH OPEN LID
		CALLOUT FOR STORM STRUCTURE RIM SAME AS T.C. WHEN IN CURB
		B-6.12 CURB & GUTTER
		ROLLED CURB & GUTTER
		REVERSE PITCH CURB & GUTTER
		OVERFLOW ARROW
		100 YR DESIGN HWL
		CONTOUR
		POWER POLE & OVERHEAD WIRE
		POWER POLE W/GUY WIRE
		STREET LIGHT

NO RECORD INFORMATION
THIS SHEET AS OF 11-1-06 JMM

9/06/06	10	NO REVISION THIS SHEET
8/22/06	9	NO REVISION THIS SHEET
7/11/06	8	NO REVISION THIS SHEET
6/30/06	7	NO REVISION THIS SHEET
4/10/06	6	STORM SIZE FROM A2 TO A3

555
 555
 555
 555
 DCK

DC	DRAWN	SCALE	SHEET	OF
CK	DC	1" = 100'	2	24
CK	DESIGNED	DATE	PROJECT	NO.
CK	JWS/WB	12/15/03	2001.029-3	
CK	BY			

INTECH CONSULTANTS, INC.
5413 WALNUT AVE. DOWNERS GROVE, ILL.
 ILLINOIS REGISTRATION No. 184-001040

ENGINEERS SURVEYORS


WISEMAN-HUGHES ENTERPRISES
975 EAST 22nd STREET
WHEATON, ILLINOIS 60187

**RESTON PONDS
UNIT 3
SYCAMORE, ILLINOIS**

UTILITY PLAN

2/02/06	5	PER CITY REVIEW
12/30/05	4	PER CITY REVIEW
10/19/05	3	KELLUM ALIGNMENT
9/19/05	2	PER CITY GRADING REVIEW
5/16/05	1	MOVE LIGHT POLE #2
DATE	NO.	REVISION

NO RECORD INFORMATION
THIS SHEET AS OF 11-1-06 JMM

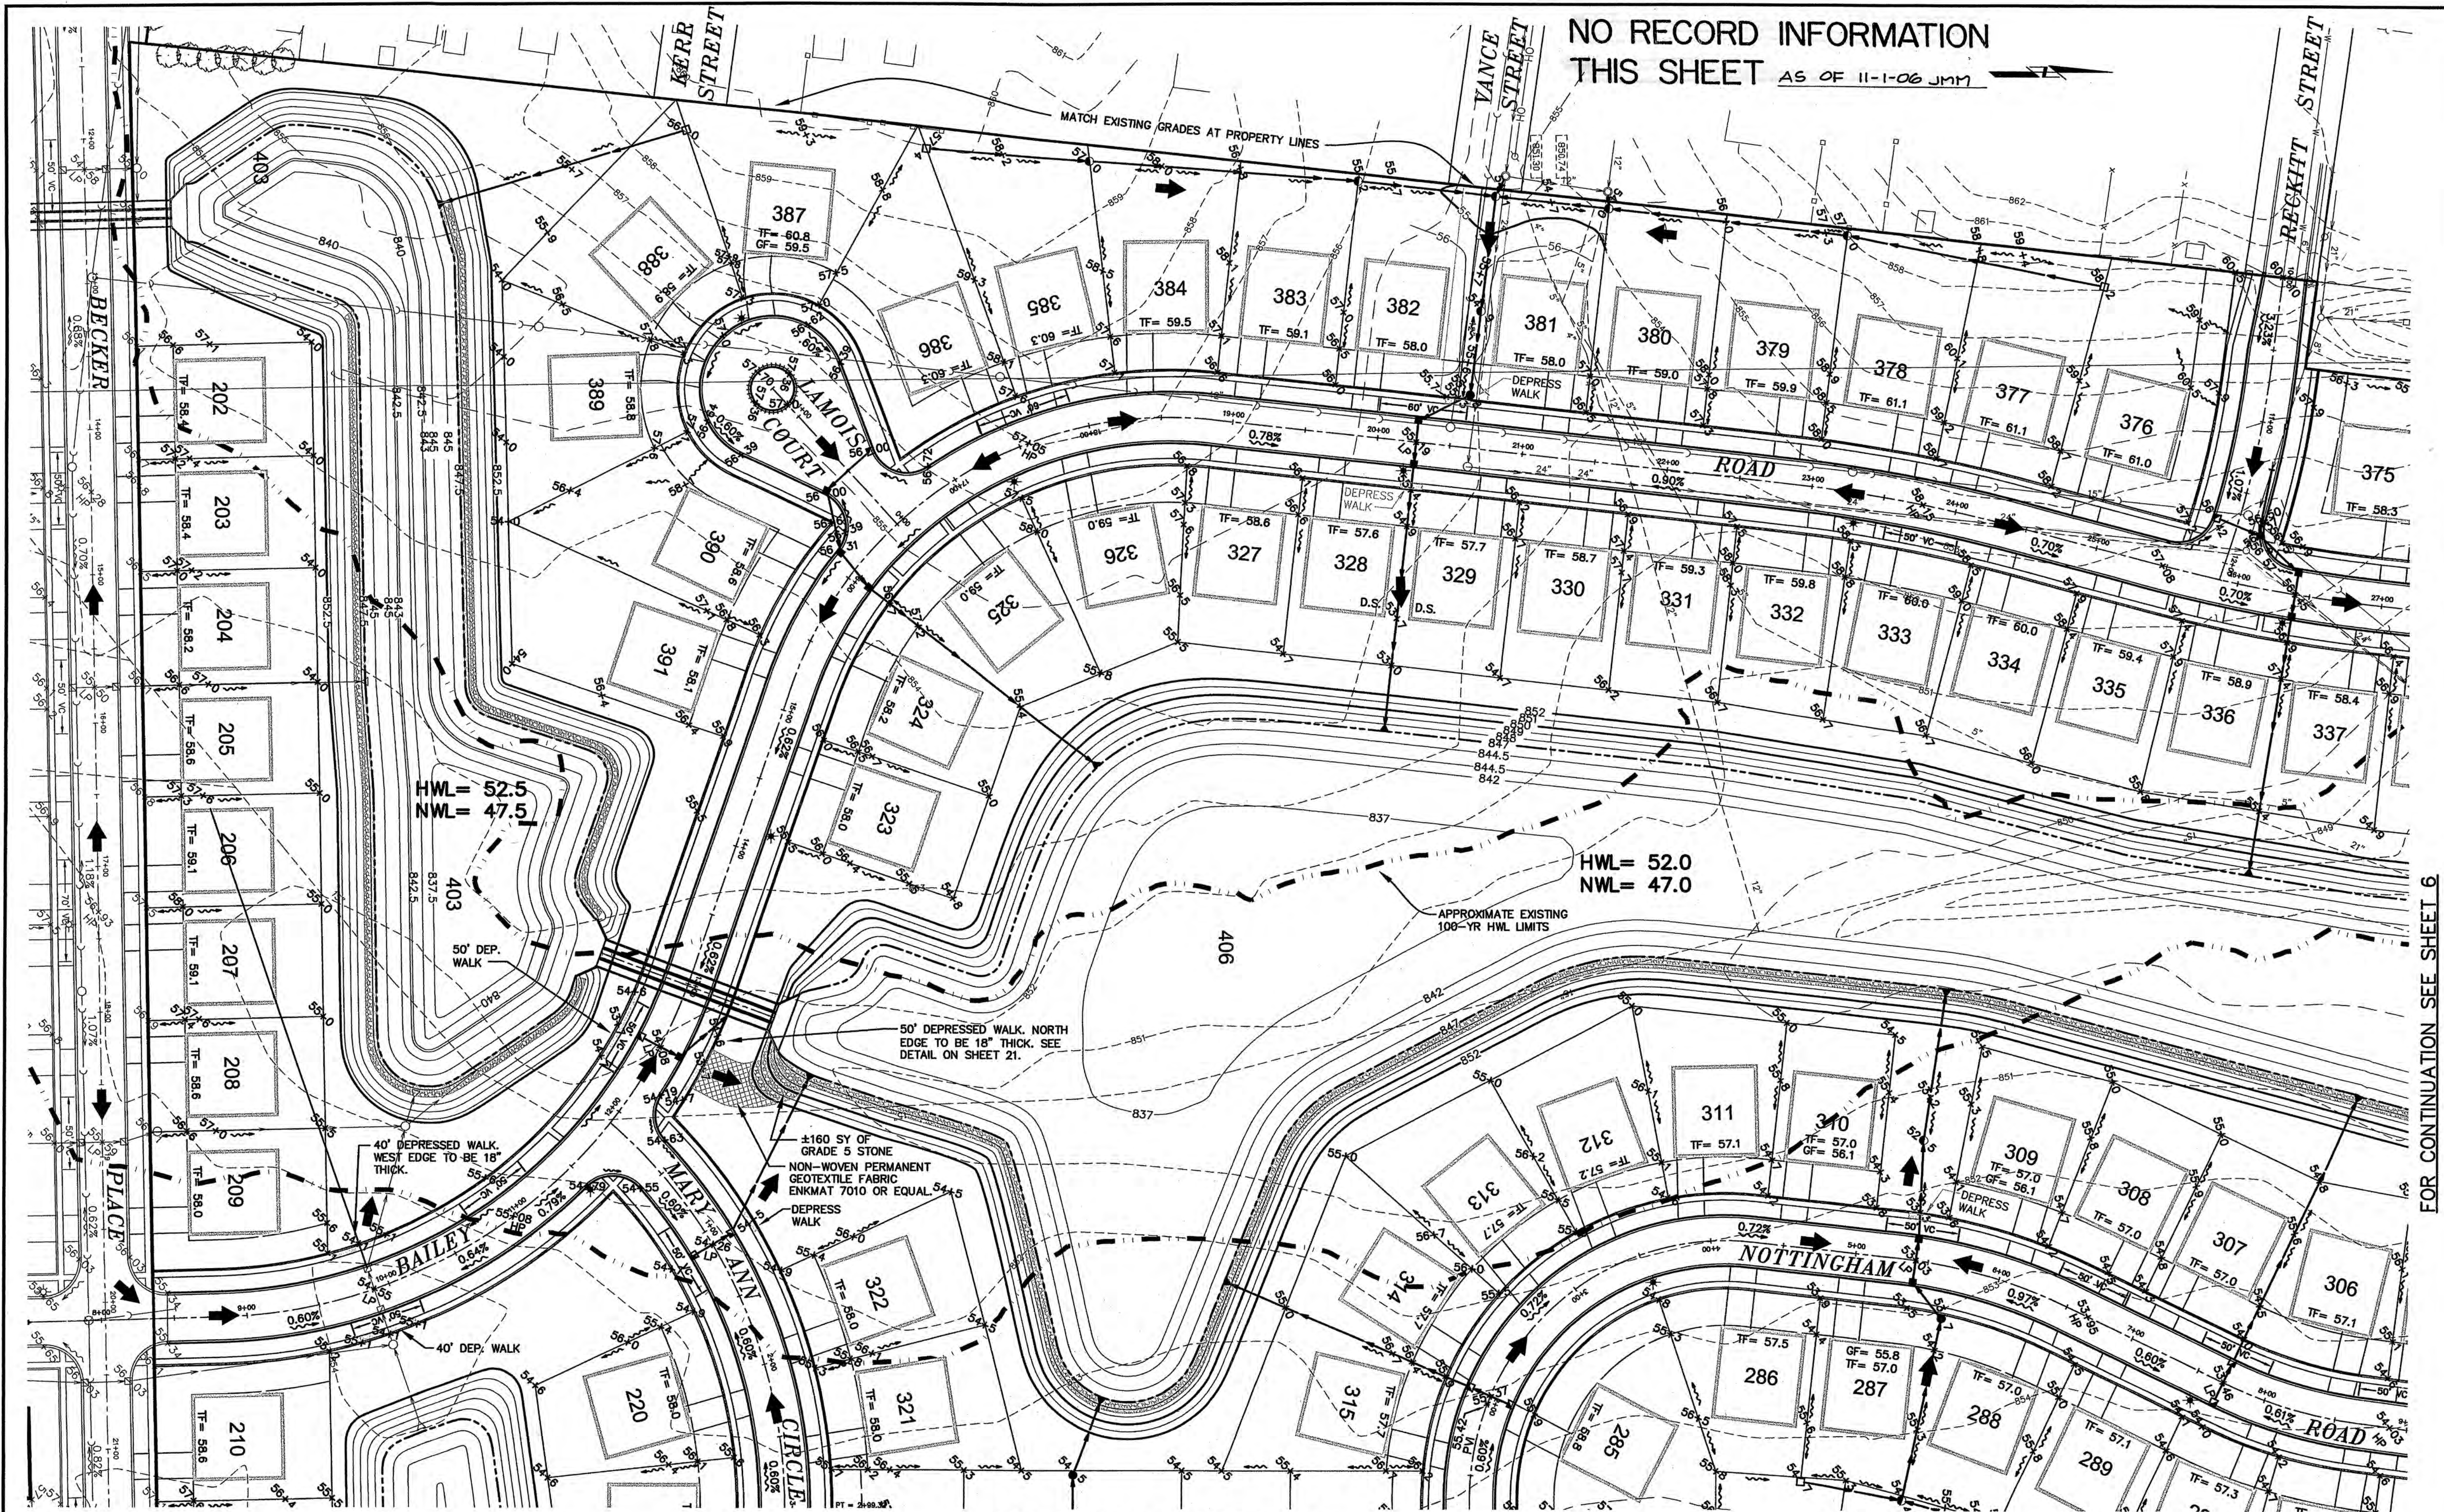

FOR CONTINUATION SEE SHEET 5

FOR CONTINUATION SEE SHEET 6

	INTECH CONSULTANTS, INC. 5413 WALNUT AVE. DOWNERS GROVE, ILL. ILLINOIS REGISTRATION No. 184-001040	ENGINEERS SURVEYORS	WISEMAN-HUGHES ENTERPRISES 975 EAST 22nd STREET WHEATON, ILLINOIS	RESTON PONDS UNIT 3 SYCAMORE, ILLINOIS	GRADING PLAN	9/06/06 10 TFS PER CITY DCK	SCALE 1" = 50'	SHEET 4 OF 24
						8/22/06 9 TFS, GFs & WALK GRADES PER CITY DCK		
						7/11/06 8 NO REVISIONS ON THIS SHEET DCK	DATE 12/15/03	PROJECT NO. 2001.029-3
						6/30/06 7 PER CITY REVIEW DCK	DESIGNED JWS/WB	
						4/10/06 6 NO REVISION ON THIS SHEET DCK	BY	
						2/02/06 5 PER CITY REVIEW DCK		
						12/30/05 4 PER CITY REVIEW DCK		
						10/19/05 3 NO REVISION ON THIS SHEET DCK		
						9/19/05 2 PER CITY GRADING REVIEW DCK		
						5/16/05 1 POND CONTOURS, DEPRESS WALK DCK		





AS OF 11-1-06 JMM

9/06/06	10	TFs PER CITY
8/22/06	9	TFs, GFs & WALK GRADES PER CITY
7/11/06	8	NO REVISIONS ON THIS SHEET
6/30/06	7	PER CITY REVIEW
4/10/06	6	NO REVISION ON THIS SHEET


DCK	DRAWN	SCALE	SHEET	OF
DCK	DCK	1" = 50'	5	24
DCK	DESIGNED	DATE	PROJECT NO.	
DCK	JWS/WB	12/15/03	2001.029-3	
DCK	BY			

GRADING PLAN

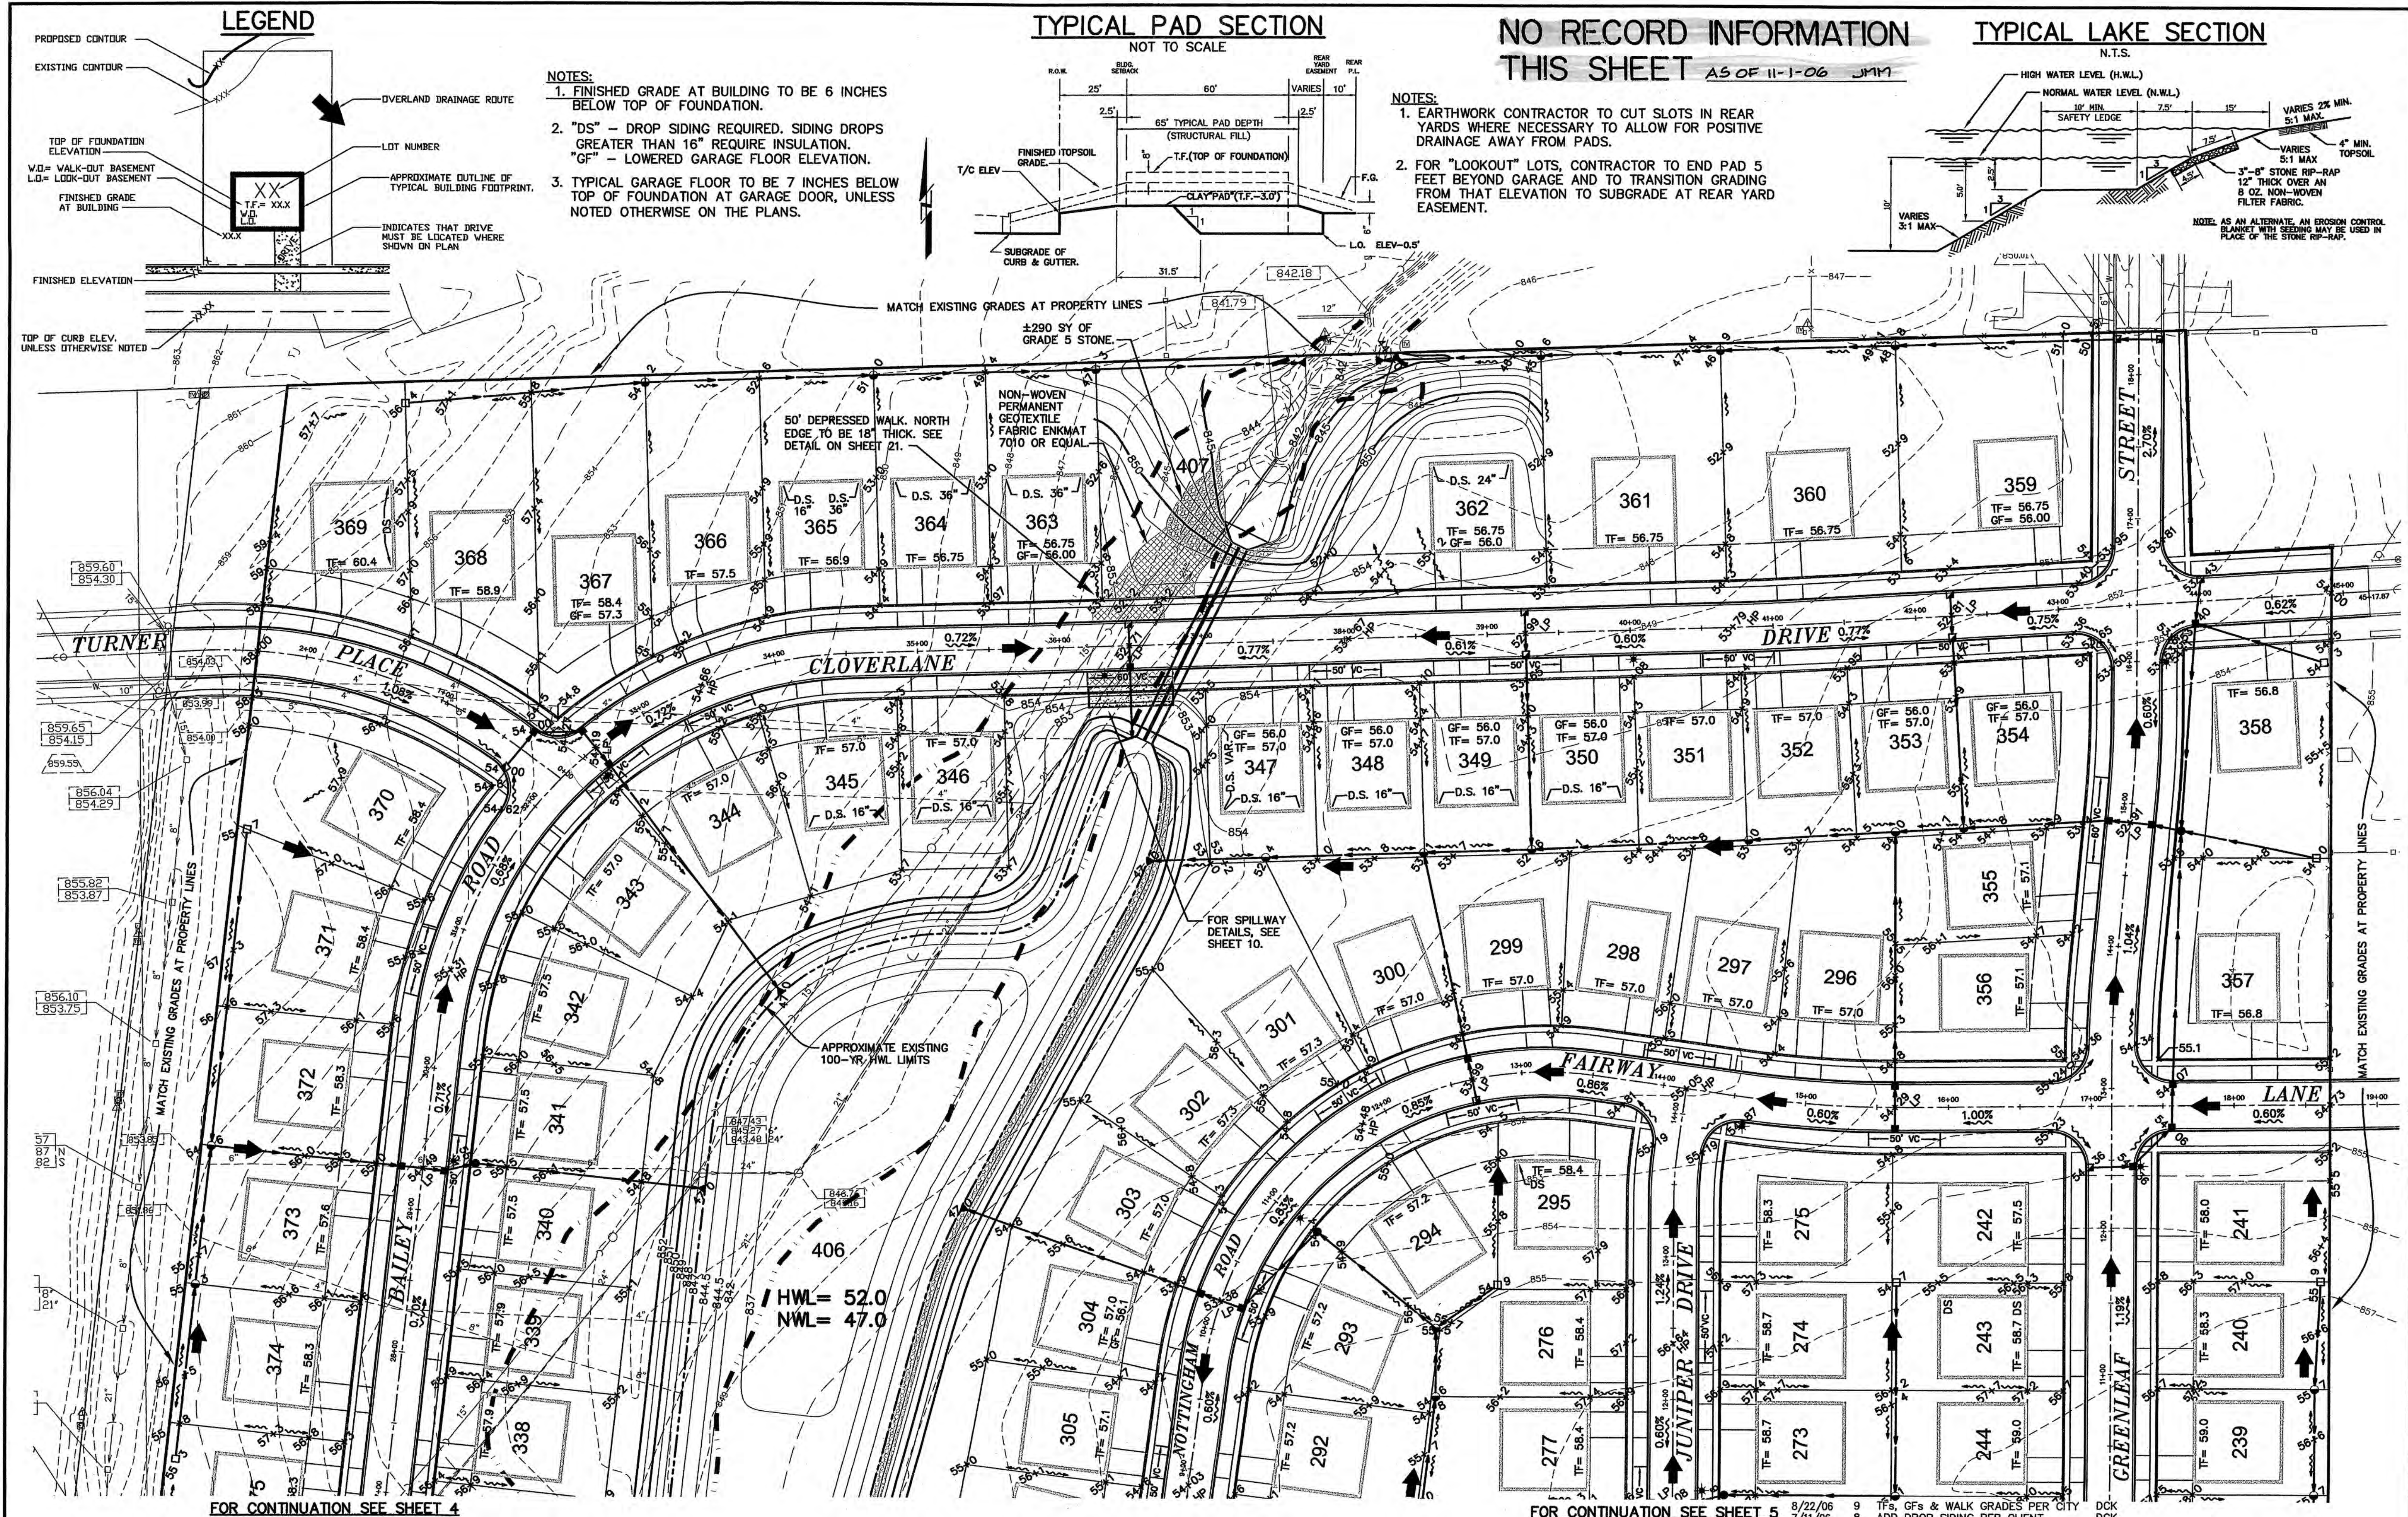

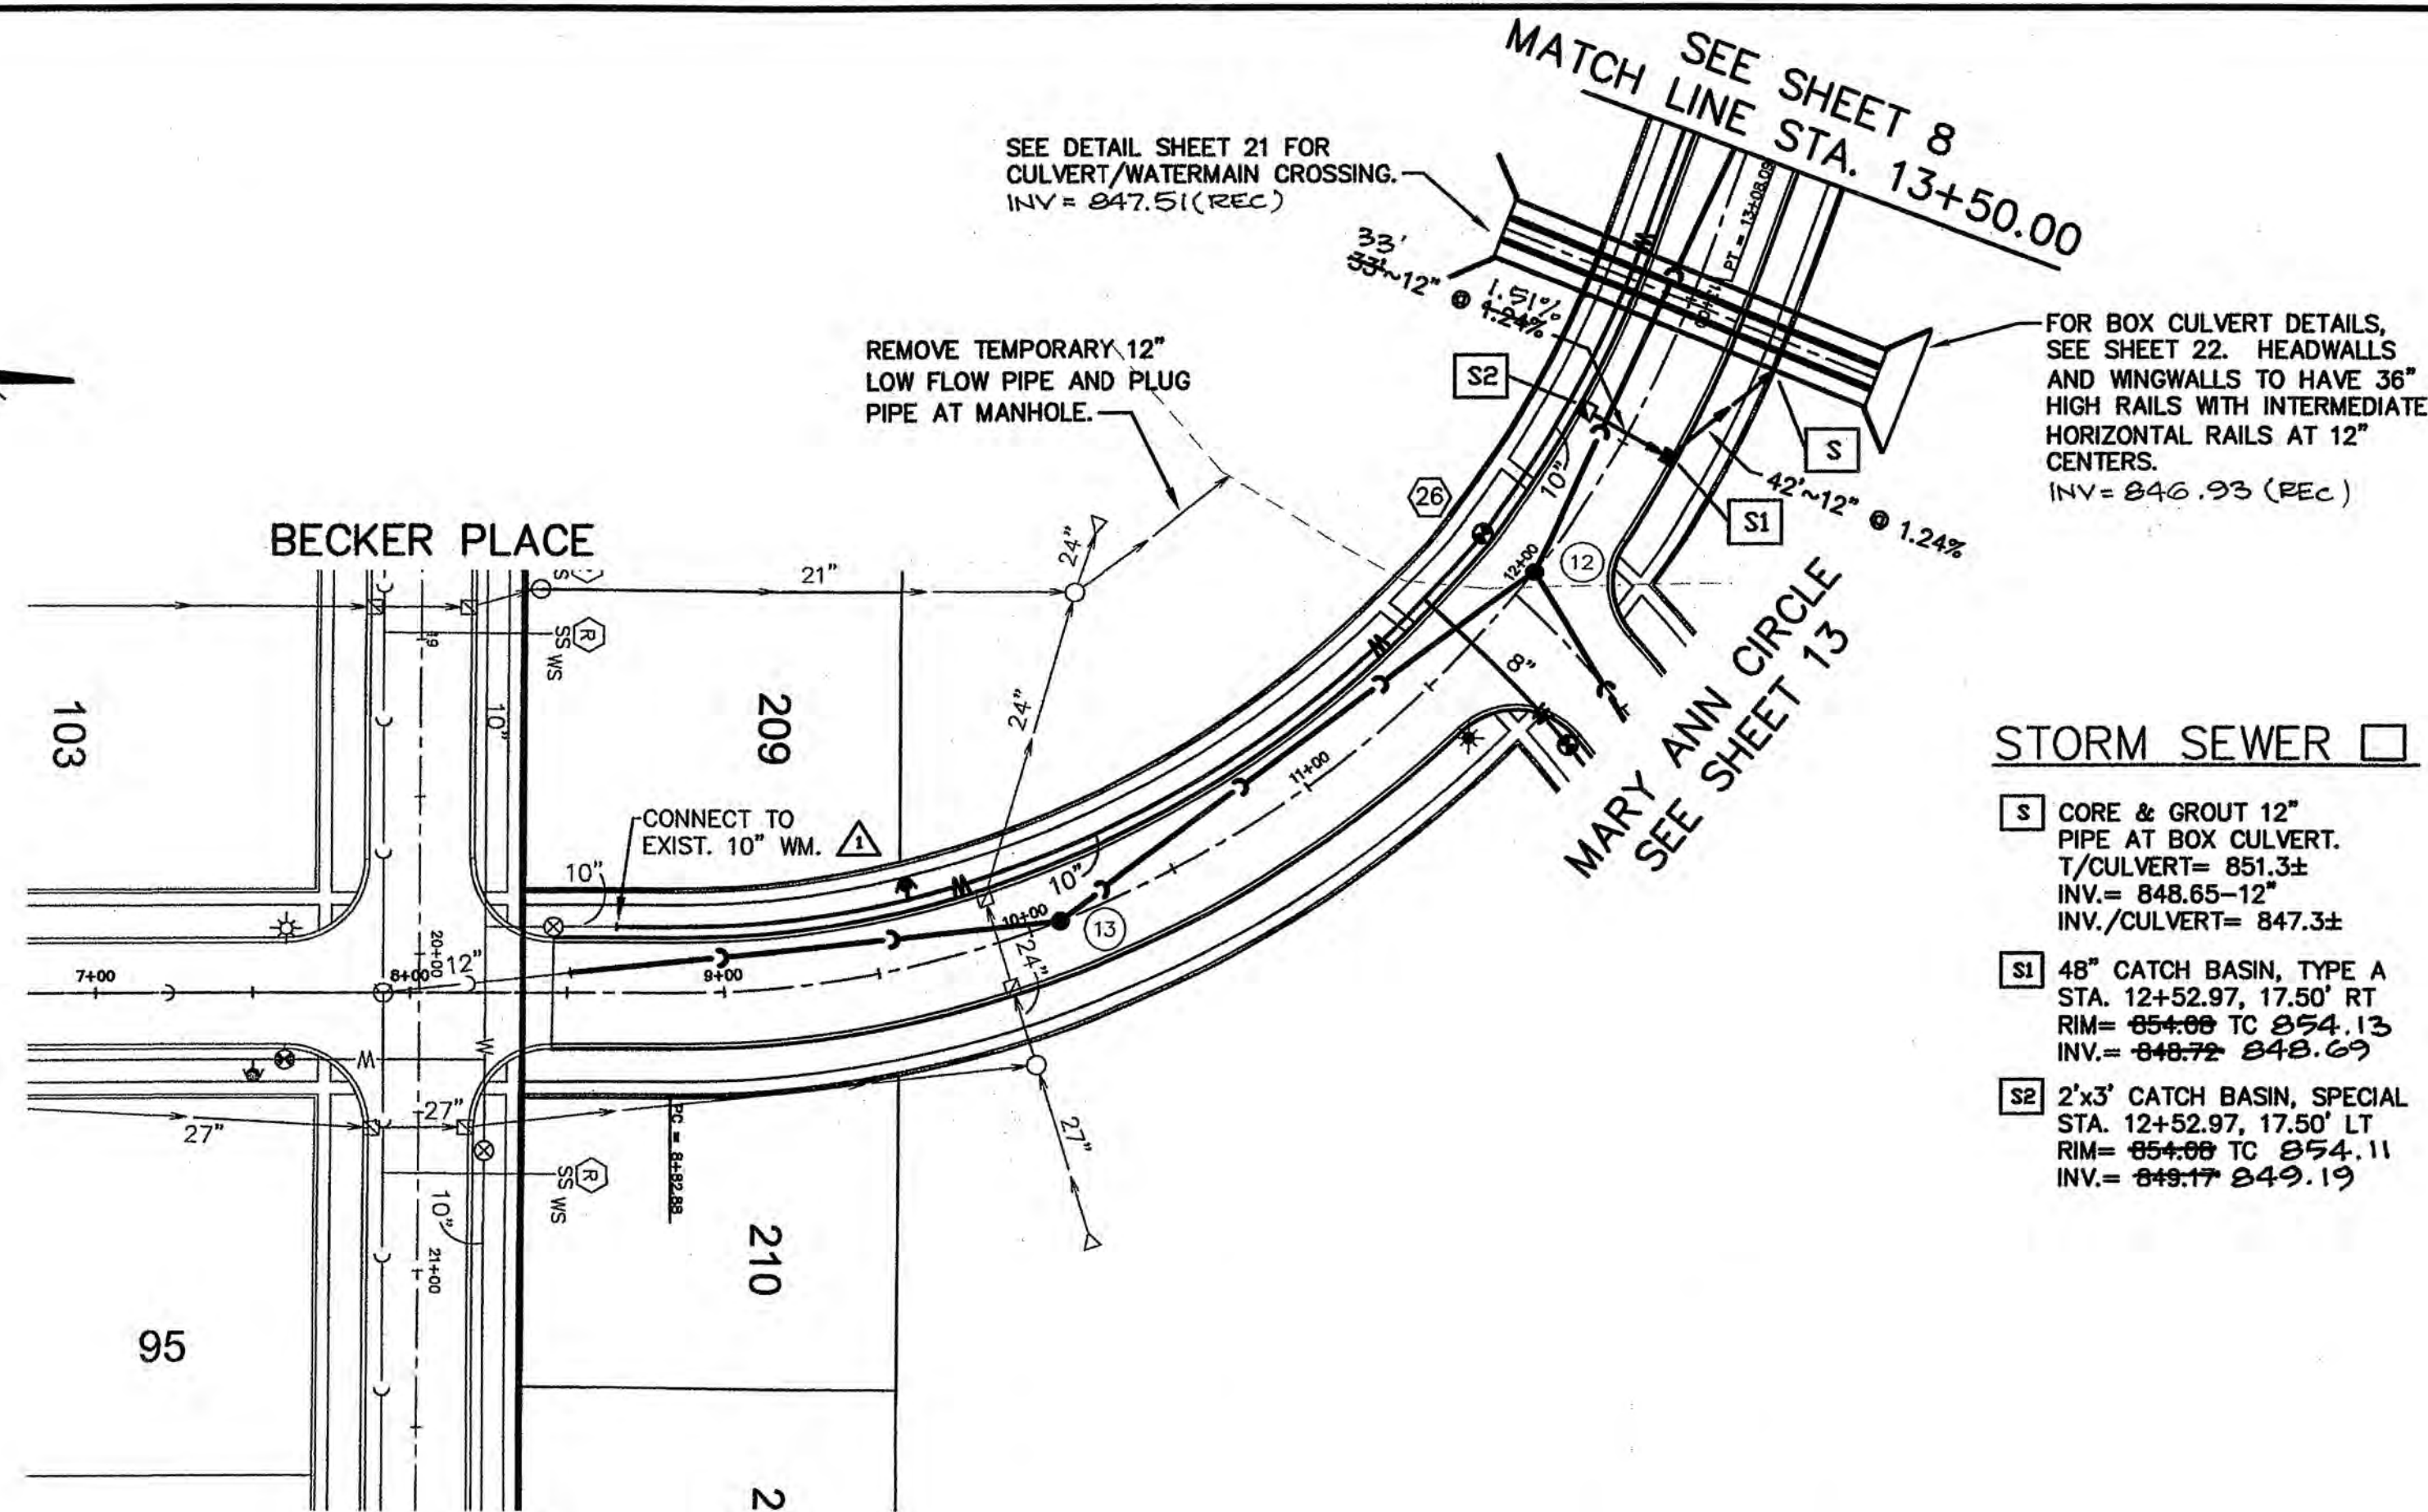

BAILEY ROAD

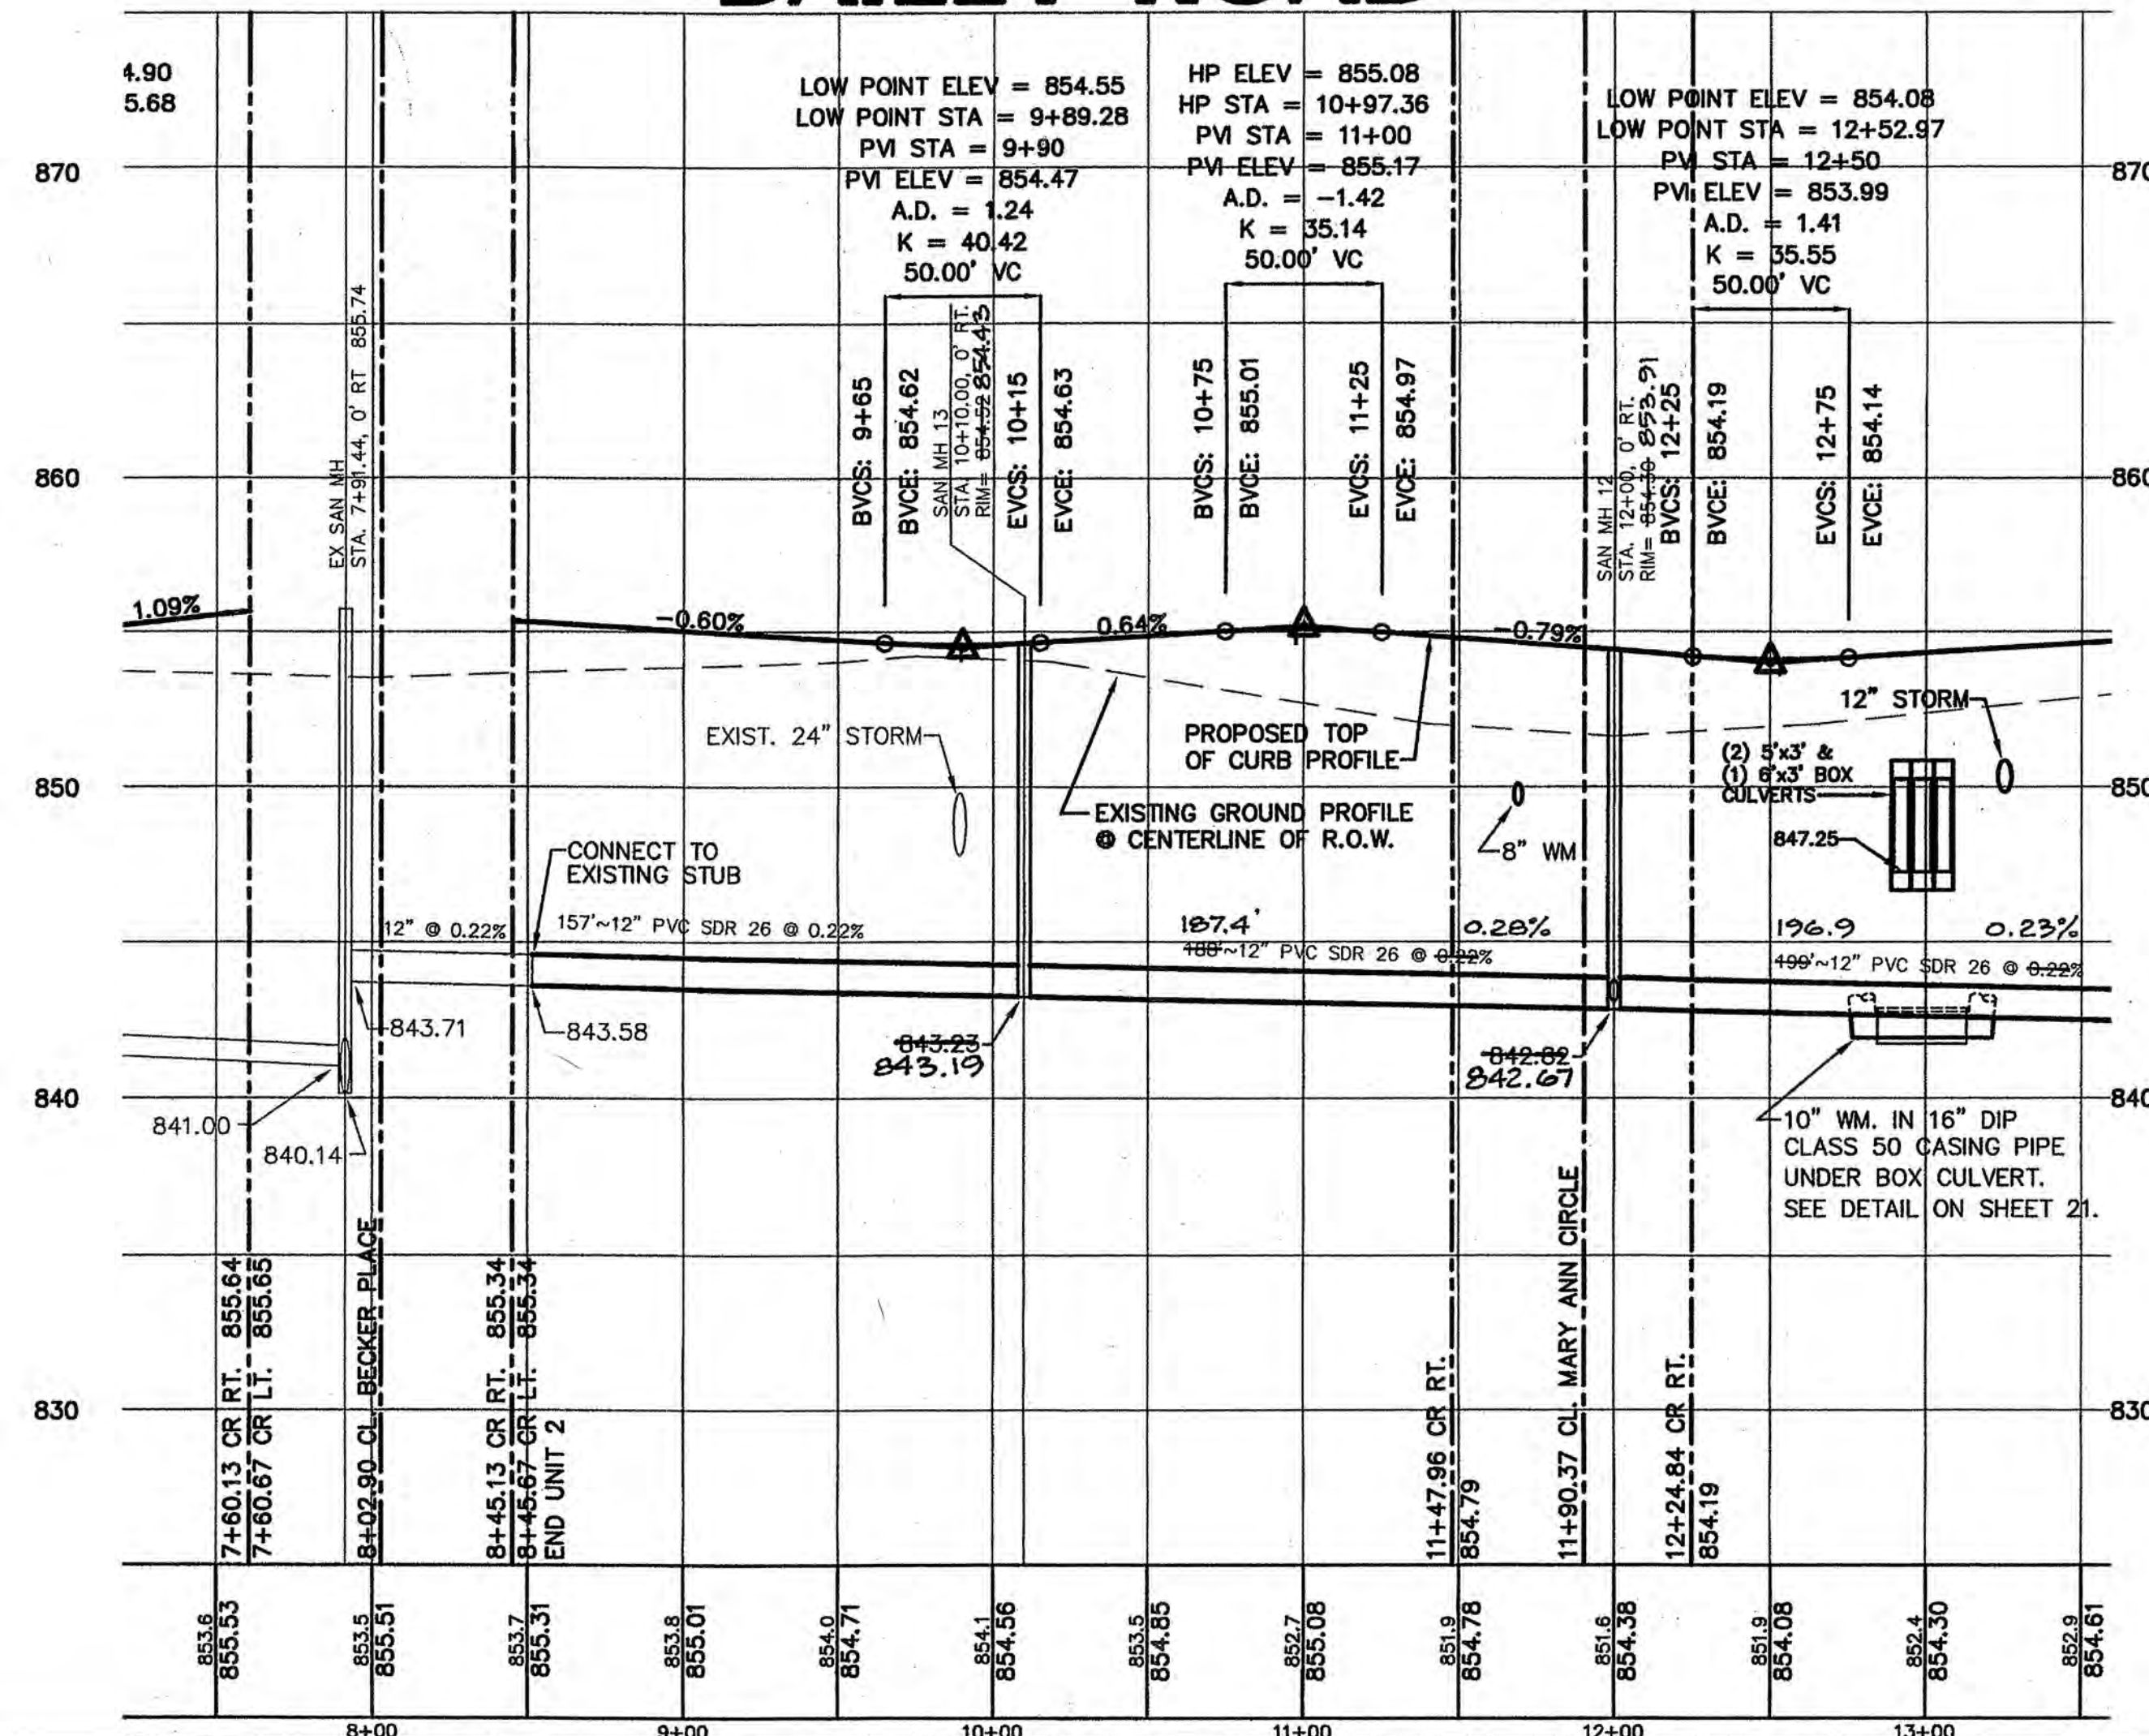

STATEMENT OF OPINION

I, John W. Stolberg, a registered Professional Engineer of the State of Illinois, (hereinafter referred to as the ENGINEER), hereby declare that this "Record Plan", has been prepared for a certain project known as Reston Ponds Unit 3 (hereinafter referred to as the PROJECT), and contains certain record information which has been obtained in part by the contractor, J&S Construction, Inc. (hereinafter referred to as the CONTRACTOR) and in part by the surveyor, Intech Consultants, Inc. (hereinafter referred to as the SURVEYOR). This "Record Plan" is not intended for use by third parties, and has been prepared for the express and limited purpose of providing the City of Sycamore with a record of certain information, specifically itemized as follows:

- Rim and invert elevations of sanitary sewer manholes, storm manholes, inlets and catchbasins as measured by the Surveyor.
- Lengths of sanitary sewers and storm sewers measured between structures by the Surveyor and slopes computed using these lengths.
- Elevations of valve vault rims and fire hydrant grade rings as measured by the Surveyor.
- Topography of the detention basins as measured by the Surveyor.
- Locations for sanitary sewer stubs and water service boxes as marked by the Contractor and measured by the Surveyor with distances computed to lot corners.

The portion of the record information detailed above that was obtained and furnished by the CONTRACTOR and the SURVEYOR, has been incorporated herein for information purposes only, and no opinion is expressed and no responsibility is assumed by the ENGINEER for the accuracy, veracity, or completeness of said information. Nevertheless, based upon the reliability of the information obtained and furnished by the CONTRACTOR and the SURVEYOR, it is my professional opinion that the specific PROJECT components detailed above have been constructed in substantial conformance to the design intent of the engineering plans with the following exception(s):

- The storm sewer between structures L15 and L16 is laid at just 0.06% and may require more frequent cleaning.
- The storm sewer between structures B10 and B16 is laid at just 0.04% and may require more frequent cleaning.
- The sanitary manhole rims have all been set lower than design grade and have been paved over. These should be raised prior to placing the final asphalt surface course.
- The 15-inch sanitary sewer between manholes 3 and 4 has been laid at 0.09% and may require more frequent cleaning. *Minimum allowable slope for 15" pipe is 0.18%.*

This statement and the record information shown constitute neither a guarantee nor a warranty, expressed or implied, as to the existence, location, or quality of the improvements installed within this PROJECT, or to compliance with the PROJECT specifications, or any other matter that was part of the work or within the control of the CONTRACTOR.

Dated this 27th day of April, 2007.

JOHN W. STOLBERG
44655
LICENSED PROFESSIONAL ENGINEER
OF
ILLINOIS
Professional Engineer No. 0631944655
Expires 11-30-07

RECORD PLAN

AS OF 11-1-06 JMM
4-27-07 JMM

9/06/06 10 NO REVISION THIS SHT JMM
8/22/06 10 NO REVISION THIS SHT JMM
7/11/06 10 NO REVISION THIS SHT JMM
6/18/06 7 NO REVISION THIS SHT JMM
4/10/06 6 NO REVISION THIS SHT JMM

02/02/06 5 PER CITY REVIEW DCK
12/30/05 4 PER CITY REVIEW DCK
10/19/05 3 NO REVISION ON THIS SHEET DCK
9/19/05 2 NO REVISION ON THIS SHEET DCK
5/16/05 1 SERVICE LOCATIONS DCK

DRAWN DCK
DESIGNED JWS/WB
SCALE HORIZ. 1" = 50'
VERT. 1" = 5'
DATE 12/15/03
SHEET 7 OF 24
PROJECT NO. 2001.029-3


INTECH CONSULTANTS, INC.
5413 WALNUT AVE. DOWNERS GROVE, ILL.
ILLINOIS REGISTRATION No. 184-001040

**ENGINEERS
SURVEYORS**

WISEMAN-HUGHES ENTERPRISES
975 EAST 22nd STREET
WHEATON, ILLINOIS

**RESTON PONDS
UNIT 3
SYCAMORE, ILLINOIS**

**PLAN & PROFILE
BAILEY ROAD**
Sta. 8+45.67 TO Sta. 13+50.00

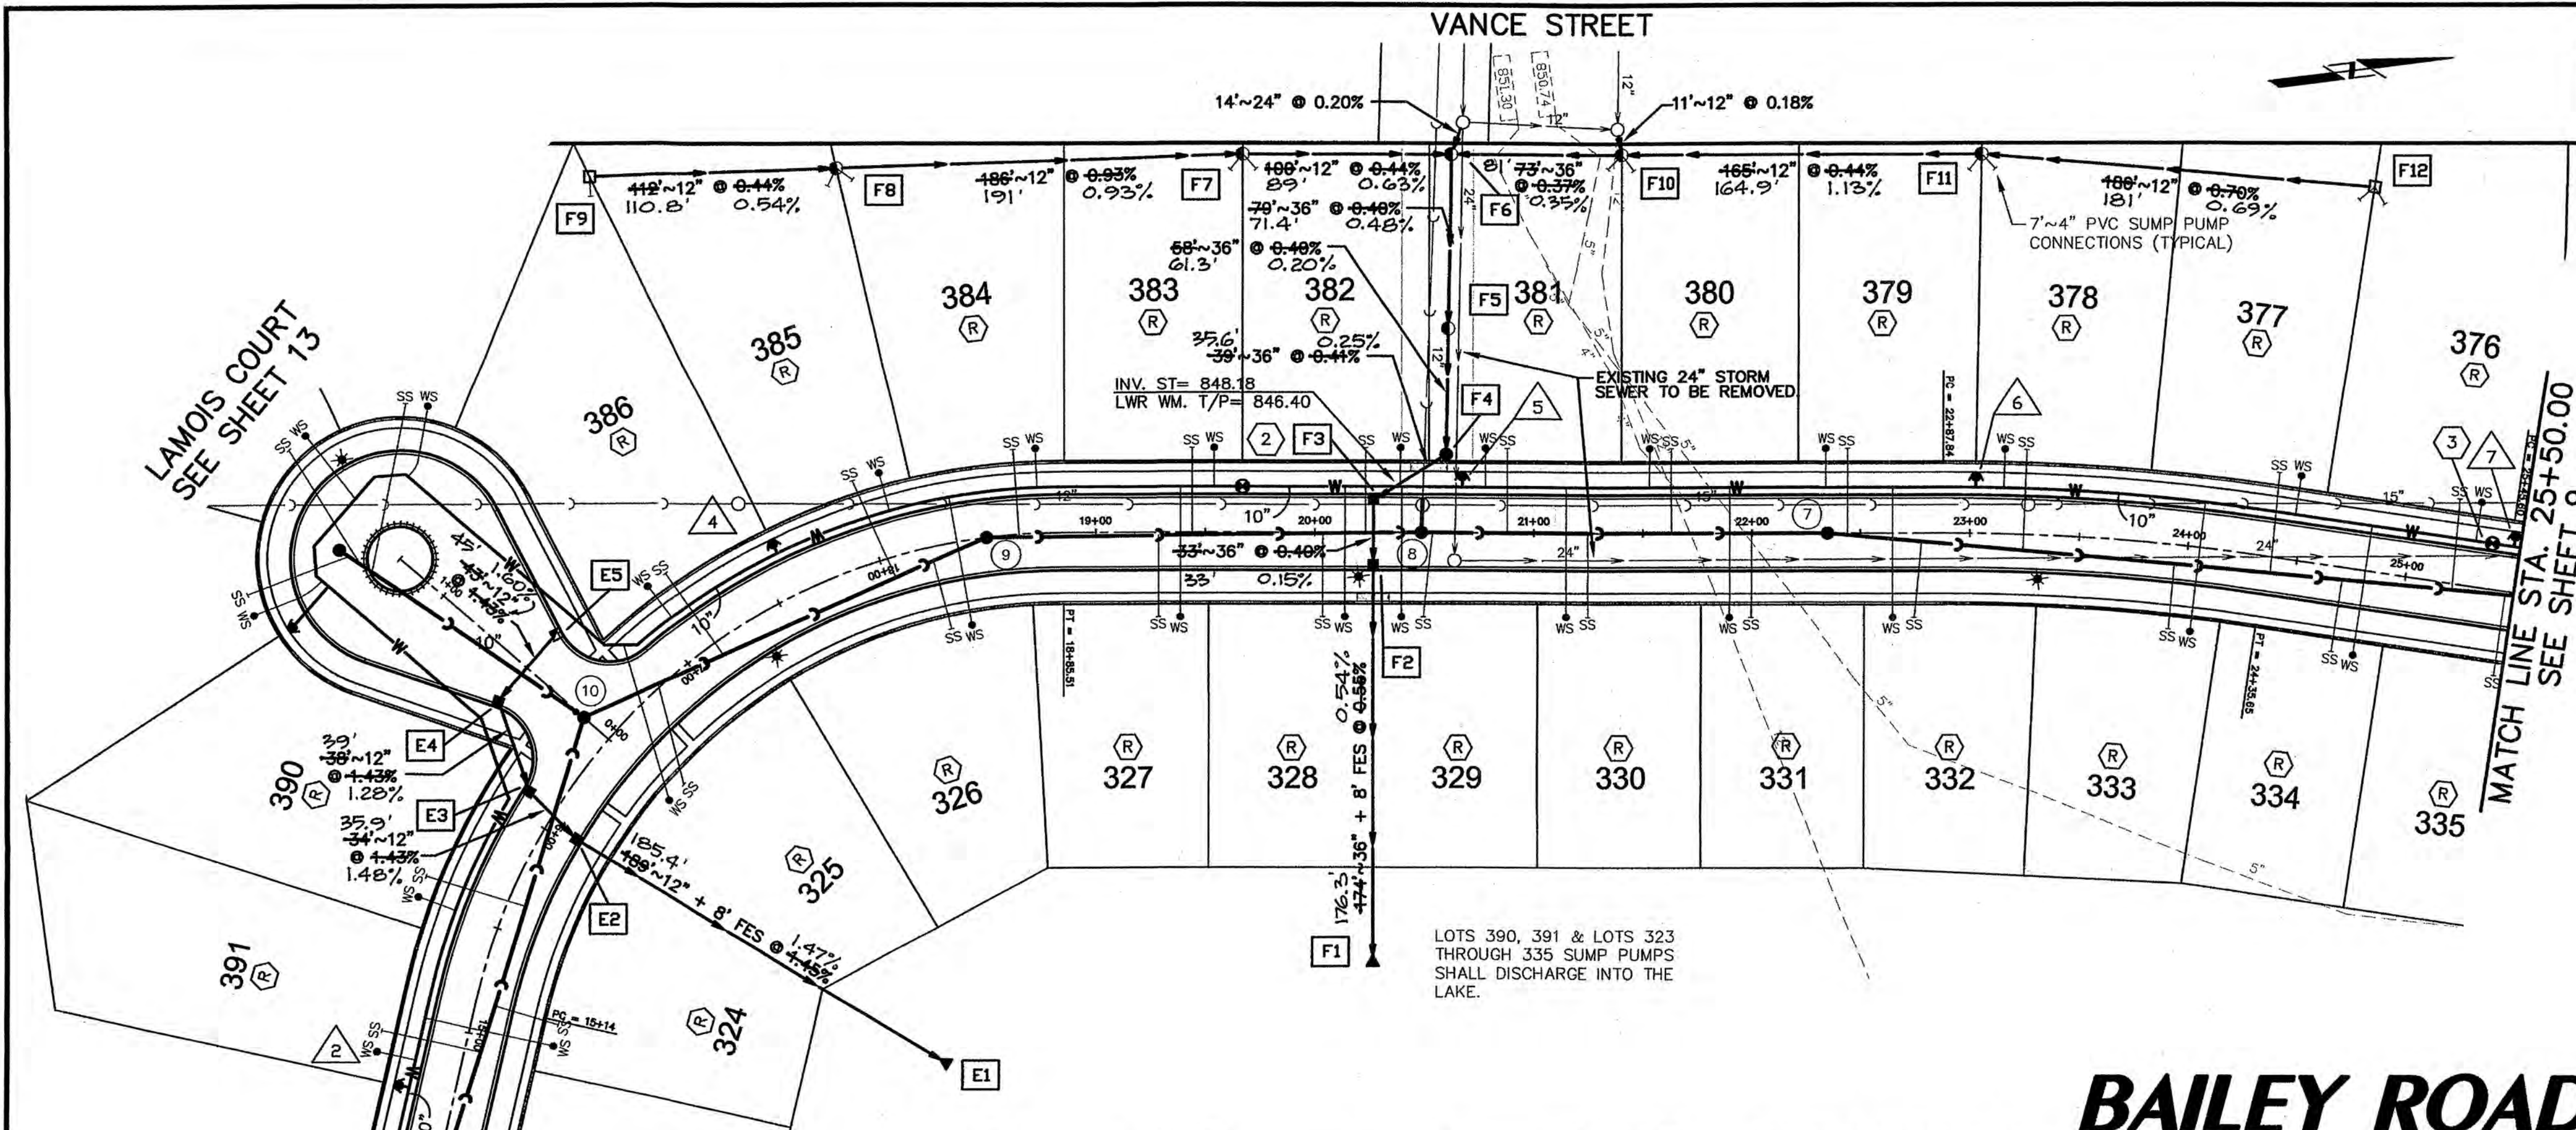

HYDRANTS

- △ FIRE HYDRANT STA. 14+69.51, 26" LT. FIN. GRD. = 855.70 856.22
- △ FIRE HYDRANT STA. 17+59.38, 26" LT. FIN. GRD. = 857.40 857.76
- △ FIRE HYDRANT STA. 20+67.23, 26" LT. FIN. GRD. = 855.20 855.62
- △ FIRE HYDRANT STA. 23+02.29, 26" LT. FIN. GRD. = 857.00 857.20
- △ FIRE HYDRANT STA. 25+47.11, 26" LT. FIN. GRD. = 857.40 857.89

STORM SEWER

- E1 12" FLARED END SECTION STA. 14+64.50, 36.00' LT. INV. = 855.80 855.86
- E2 48" CATCH BASIN, TYPE A STA. 16+03.50, 17.50' RT. RIM = 856.10 TC 856.00 INV. = 848.80 849.84
- E3 48" CATCH BASIN, TYPE A STA. 16+10.24, 17.50' LT. RIM = 856.22 TC 856.07 INV. = 850.34 850.37
- E4 48" CATCH BASIN, TYPE A STA. 0+48.56, 22.51' LT. RIM = 856.00 TC 855.79 INV. = 851.50 851.59
- E5 2'x3' CATCH BASIN, SPECIAL STA. 0+48.56, 22.51' RT. RIM = 856.00 TC 855.84 INV. = 851.50 851.59
- F1 36" FLARED END SECTION INV. = 847.00 847.03
- F2 60" CATCH BASIN, TYPE A STA. 20+28.65, 17.50' RT. RIM = 855.19 TC 855.26 INV. = 848.04 848.03
- F3 60" CATCH BASIN, TYPE A STA. 20+28.65, 17.50' LT. RIM = 855.19 TC 855.08 INV. = 848.14 848.08
- F4 60" MANHOLE, TYPE A, C.L. STA. 20+64.50, 36.00' LT. RIM = 855.80 855.86 INV. = 848.50 848.17
- F5 36"x24" TEE WITH TYPE 8 GRATE RIM = 854.90 854.92 INV. = 848.50 848.29
- F6 72" MANHOLE, TYPE A, O.L. RIM = 854.10 854.09 INV. = 850.74 850.35
- F7 48" MANHOLE, TYPE A, O.L. RIM = 855.20 855.09 INV. = 848.85 848.04
- F8 48" MANHOLE, TYPE A, O.L. RIM = 855.20 855.09 INV. = 848.85 848.04
- F9 24" INLET, TYPE A RIM = 857.40 857.28 INV. = 853.40 853.29
- F10 72" MANHOLE, TYPE A, O.L. RIM = 854.00 854.14 INV. = 852.21 850.95
- F11 48" MANHOLE, TYPE A, O.L. RIM = 857.00 856.97 INV. = 852.94 852.81
- F12 24" INLET, TYPE A RIM = 858.20 858.28 INV. = 854.20 854.06


VALVES

- ① 10" VALVE IN 60" VAULT STA. 13+90.00, 21' LT. RIM = 855.10 854.97
- ② 10" VALVE IN 60" VAULT STA. 19+67.06, 21' LT. RIM = 855.70 855.70
- ③ 10" VALVE IN 60" VAULT STA. 25+37.07, 21' LT. RIM = 857.20 857.27

NOTES:

- SANITARY MANHOLES SHALL BE INITIALLY ADJUSTED SO THAT THEY ARE BURIED BELOW THE BITUMINOUS BINDER COURSE AND THEN ADJUSTED TO FINAL GRADE AND SEALED WITH CANUSA WRAPID SEAL SYSTEM JUST PRIOR TO PLACING FINAL BITUMINOUS SURFACE.
- AFTER NEW 12" AND 15" SANITARY SEWER IS INSTALLED, EXISTING 12" AND 15" SANITARY SEWER SHALL BE FILLED WITH CONTROLLED LOW STRENGTH MATERIAL (FLOWABLE FILL). FRAMES AND COVERS FROM EACH OF THE EXISTING MANHOLES SHALL BE REMOVED AND MANHOLES SHALL BE FILLED WITH FLOWABLE FILL. INSTALLATION OF THE FLOWABLE FILL, TO THE SATISFACTION OF THE CITY ENGINEER, SHALL BE FIELD VERIFIED.
- 4" SUMP PUMP LINES TO BE CONNECTED TO STORM STRUCTURES AT ±4' DEPTHS.
- ALL STORM SEWER IN THE RIGHT-OF-WAY AND SIDEYARDS TO HAVE GASKETED JOINTS.

BAILEY ROAD

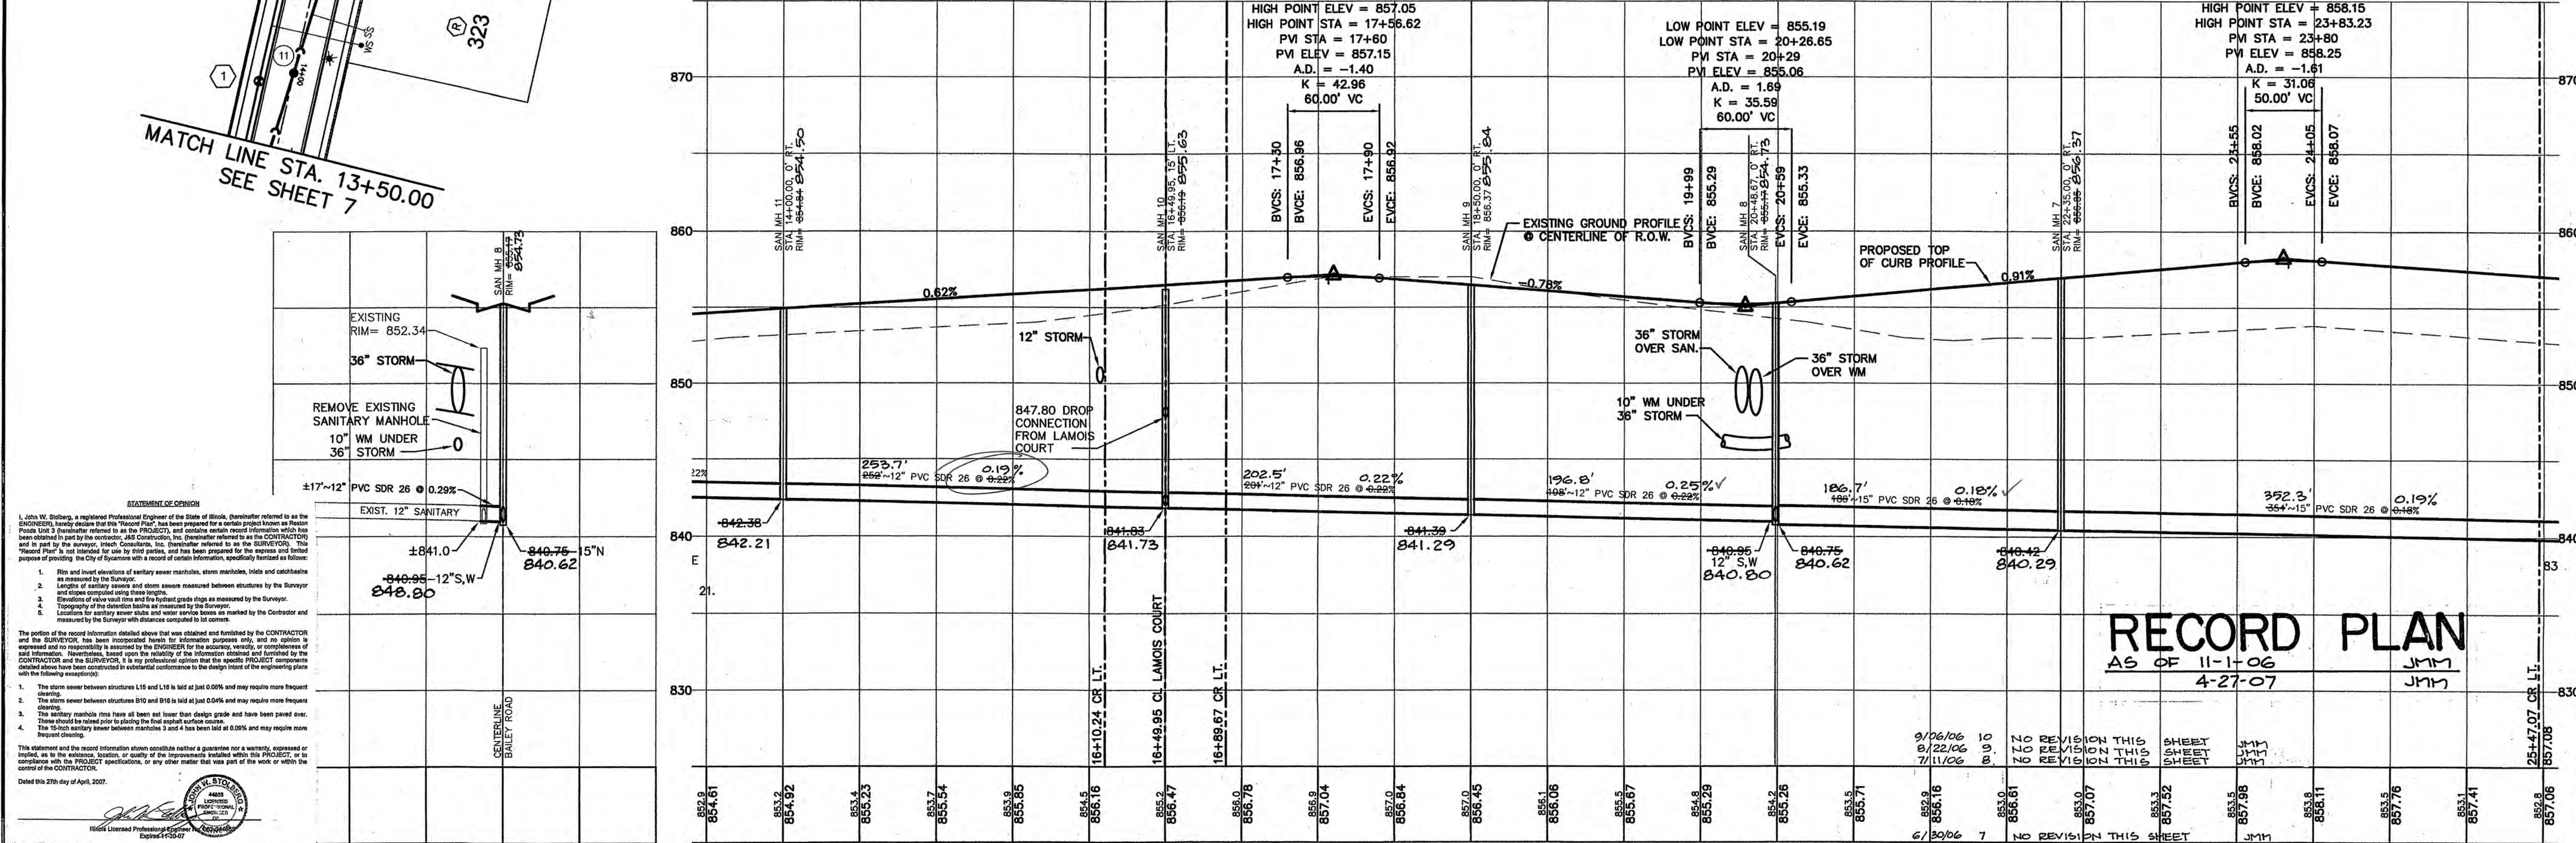


RECORD PLAN


AS OF 11-1-06
4-27-07

INTECH CONSULTANTS, INC. 5413 WALNUT AVE. DOWNERS GROVE, ILL. ILLINOIS REGISTRATION No. 184-001040	ENGINEERS SURVEYORS	WISEMAN-HUGHES ENTERPRISES 975 EAST 22nd STREET WHEATON, ILLINOIS	RESTON PONDS UNIT 3 SYCAMORE, ILLINOIS	PLAN & PROFILE BAILEY ROAD Sta. 13+50.00 TO Sta. 25+50.00	DATE	NO.	REVISION	BY	JWS/WB	DATE	12/15/03	PROJECT NO.	2001.029-3
					2/02/06	5	PER CITY REVIEW						

CONCRETE SPILLWAY

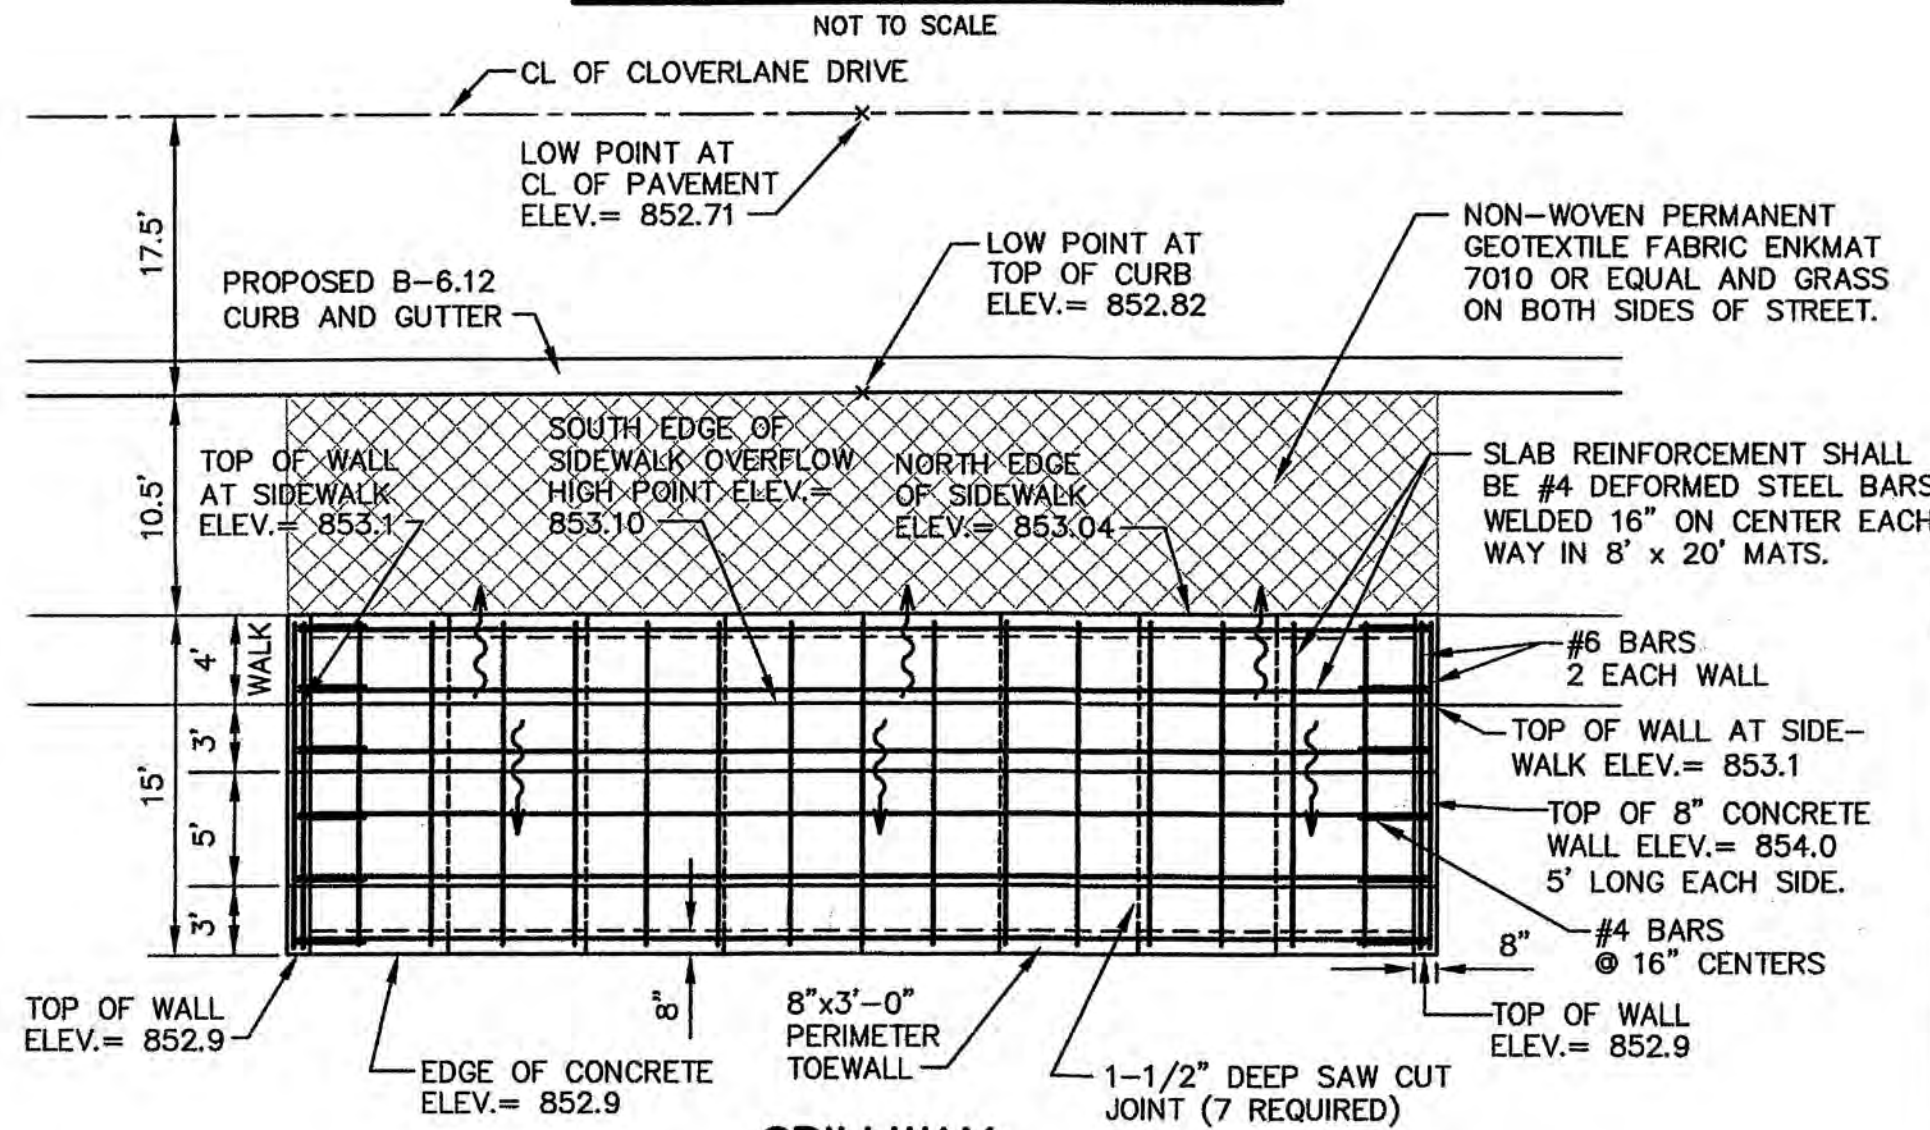

SPILLWAY PLAN

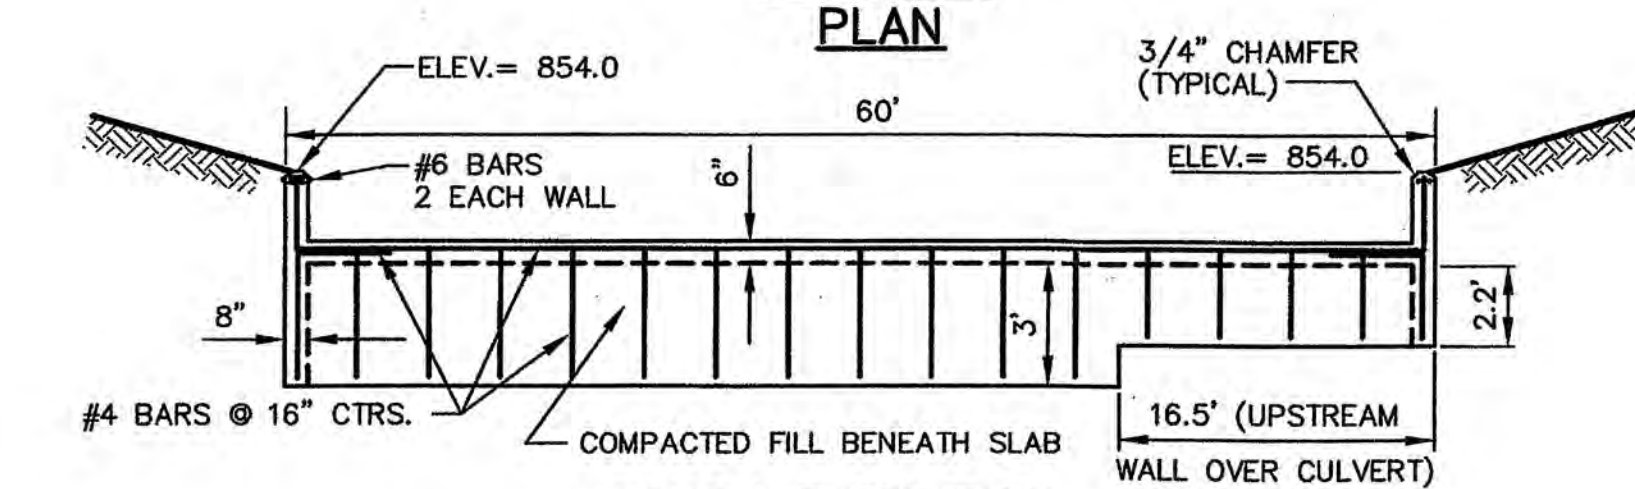

SOUTH ELEVATION

NOTES:

1. THE REINFORCED CONCRETE SPILLWAY SHALL BE CONSTRUCTED IN ACCORDANCE WITH THE APPLICABLE SECTIONS OF THE ILLINOIS DEPARTMENT OF TRANSPORTATION "STANDARD SPECIFICATIONS FOR ROAD AND BRIDGE CONSTRUCTION" LATEST EDITION.
2. CLASS S1 CONCRETE SHALL BE USED FOR THE ENTIRE SPILLWAY.
3. COMpressive STRENGTH OF CONCRETE SHALL NOT BE LESS THAN 3,000 PSI AT 28 DAYS.
4. ALL REINFORCING STEEL SHALL BE GRADE 40 MINIMUM.
5. A CONSTRUCTION JOINT WILL PERMITTED 12" BELOW THE TOP OF THE SPILLWAY.

NOTES:

1. SANITARY MANHOLES SHALL BE INITIALLY ADJUSTED SO THAT THEY ARE BURIED BELOW THE BITUMINOUS BINDER COURSE AND THEN ADJUSTED TO FINAL GRADE AND SEALED WITH CANUSA WRAPID SEAL SYSTEM JUST PRIOR TO PLACING FINAL BITUMINOUS SURFACE.
2. 4" SUMP PUMP LINES TO BE CONNECTED TO STORM STRUCTURES AT ±4' DEPTHS.
3. STORM SEWER TRENCH FOR L8 TO L9, L20 TO L21 AND M7 TO M8 STREET CROSSING SHALL BE UNDERCUT AN ADDITIONAL 12" AND FILLED WITH CA-7 BEDDING STONE.
4. ALL STORM SEWER IN THE RIGHT-OF-WAY AND SIDEYARDS TO HAVE GASKETED JOINTS.

VALVES



- 5 8" VALVE IN 48" VAULT STA. 37+89.96, 21' LT RIM = 853.7 853.76
- 6 8" VALVE IN 48" VAULT STA. 43+15.56, 21' LT RIM = 853.5 854.55

HYDRANTS


- 7 FIRE HYDRANT STA. 37+79.96, 26' LT FIN. GRD. = 853.9 854.27
- 8 FIRE HYDRANT STA. 40+68.62, 26' LT FIN. GRD. = 854.1 854.34

SANITARY SEWER MANHOLE 45-19

L1 15" FLARED END SECTION INV. = 842.00 842.00	M1 36" FLARED END SECTION INV. = 847.00 846.83
L2 48" MANHOLE, TYPE A, O.L. RIM = 846.90 846.86 INV. = 842.50-12" 842.31 INV. = 842.39-15" 842.31	M2 60" MANHOLE, TYPE A, O.L. RIM = 852.40 852.45 INV. = 847.15 847.25
L3 48" MANHOLE, TYPE A, O.L. RIM = 848.80 848.61 INV. = 843.47 843.25	M3 72" MANHOLE, TYPE A, O.L. RIM = 853.10 853.19 INV. = 848.20-15" 848.16 INV. = 847.45-30" 847.45
L4 48" MANHOLE, TYPE A, O.L. RIM = 848.80 848.80 INV. = 844.34 844.03	M4 60" MANHOLE, TYPE A, O.L. RIM = 852.60 852.63 INV. = 848.30-12" 848.39 INV. = 847.61-30" 847.70
L5 2'x3' CATCH BASIN, SPECIAL STA. 18+24.76, 17.50' LT (GREENLEAF ST.) RIM = 850.00 TC 850.14 INV. = 845.35 845.34	M5 2'x3' CATCH BASIN, SPECIAL STA. 39+26.69, 17.50' RT RIM = 853.06 TC 852.94 INV. = 849.05 849.01
L6 2'x3' CATCH BASIN, SPECIAL STA. 44+00.74, 17.50' LT RIM = 853.49 TC 853.40 INV. = 849.53 849.49	M6 2'x3' CATCH BASIN, SPECIAL STA. 39+26.69, 17.50' LT RIM = 853.06 TC 853.00 INV. = 849.20 849.07
L7 48" CATCH BASIN, TYPE A STA. 43+95.42, 17.50' RT RIM = 853.40 TC 853.47 INV. = 849.18-12" 850.20 INV. = 849.30-18" 849.43	M7 60" MANHOLE, TYPE A, O.L. RIM = 853.06 853.07 INV. = 847.94-27" 847.90 INV. = 847.89-30" 847.90
L8 24" INLET, TYPE A STA. 44+83.87, 48.00' RT RIM = 854.30 854.25 INV. = 850.55 850.61	M8 60" MANHOLE, TYPE A, O.L. RIM = 854.00 853.78 INV. = 849.10-15" 849.07 INV. = 848.34-24" 848.37 INV. = 848.14-27" 848.17
L9 2'x3' CATCH BASIN, SPECIAL STA. 42+25.26, 17.50' LT RIM = 852.81 TC 852.52 INV. = 849.06 849.12	M9 48" MANHOLE, TYPE A, O.L. RIM = 854.40 854.22 INV. = 848.51-21" 848.50 INV. = 848.47-15" 848.50 INV. = 848.44-24" 848.50
L10 2'x3' CATCH BASIN, SPECIAL STA. 42+25.26, 17.50' LT RIM = 852.81 TC 852.89 INV. = 848.91 848.86	

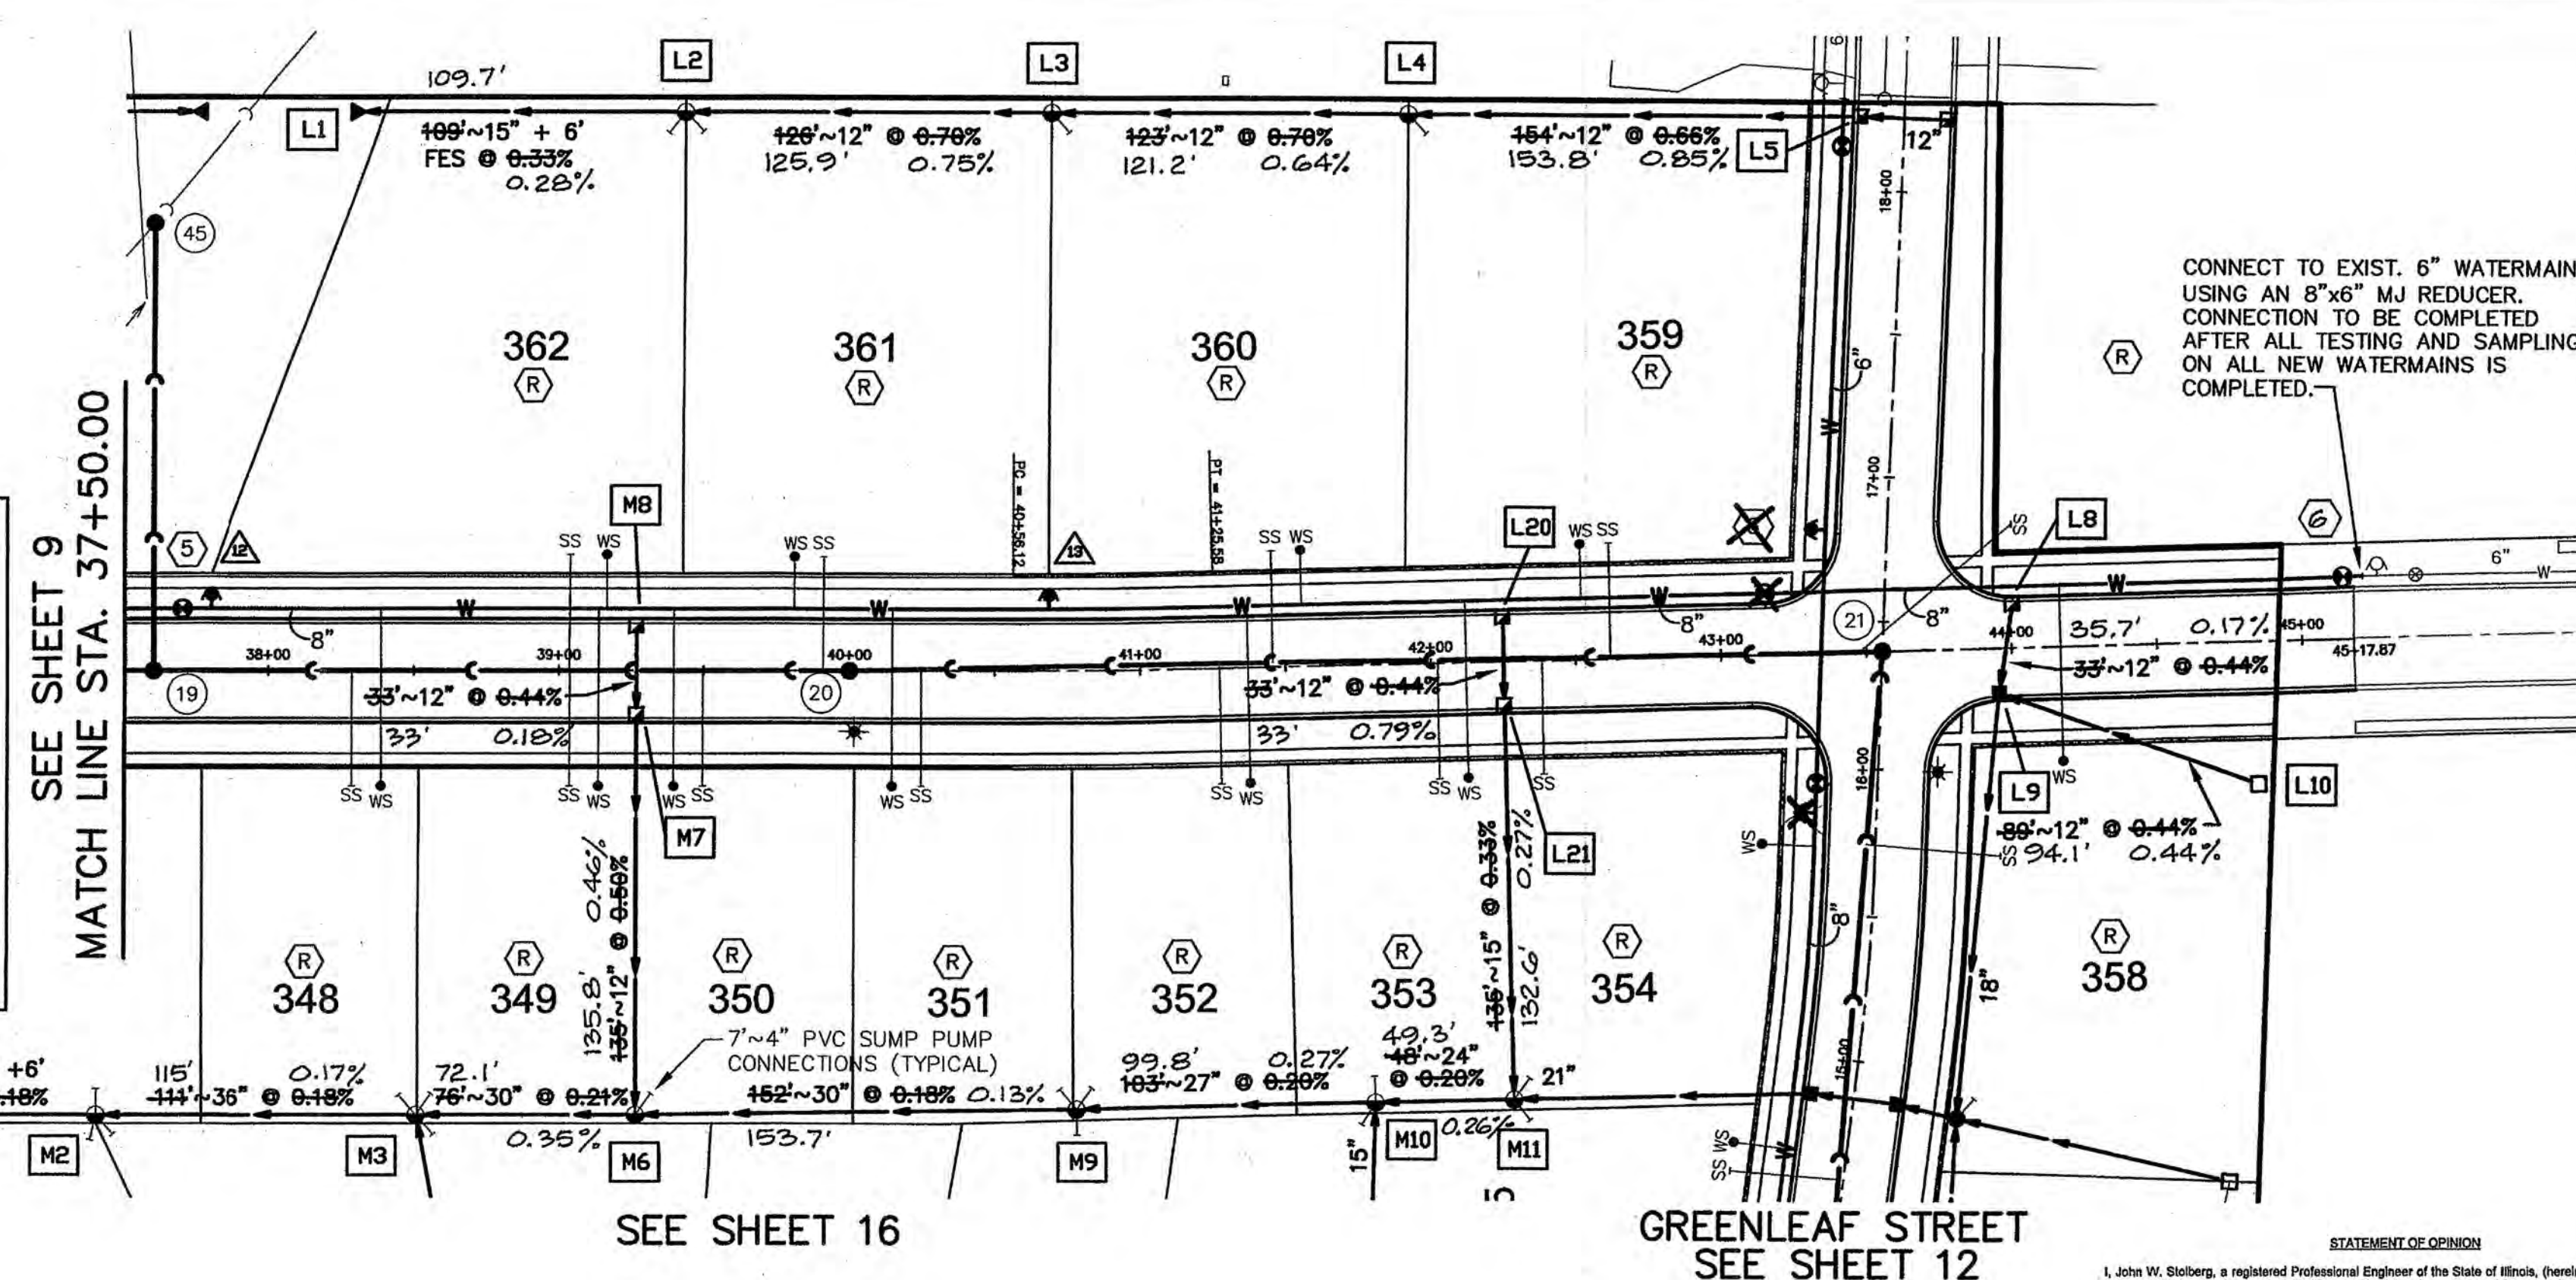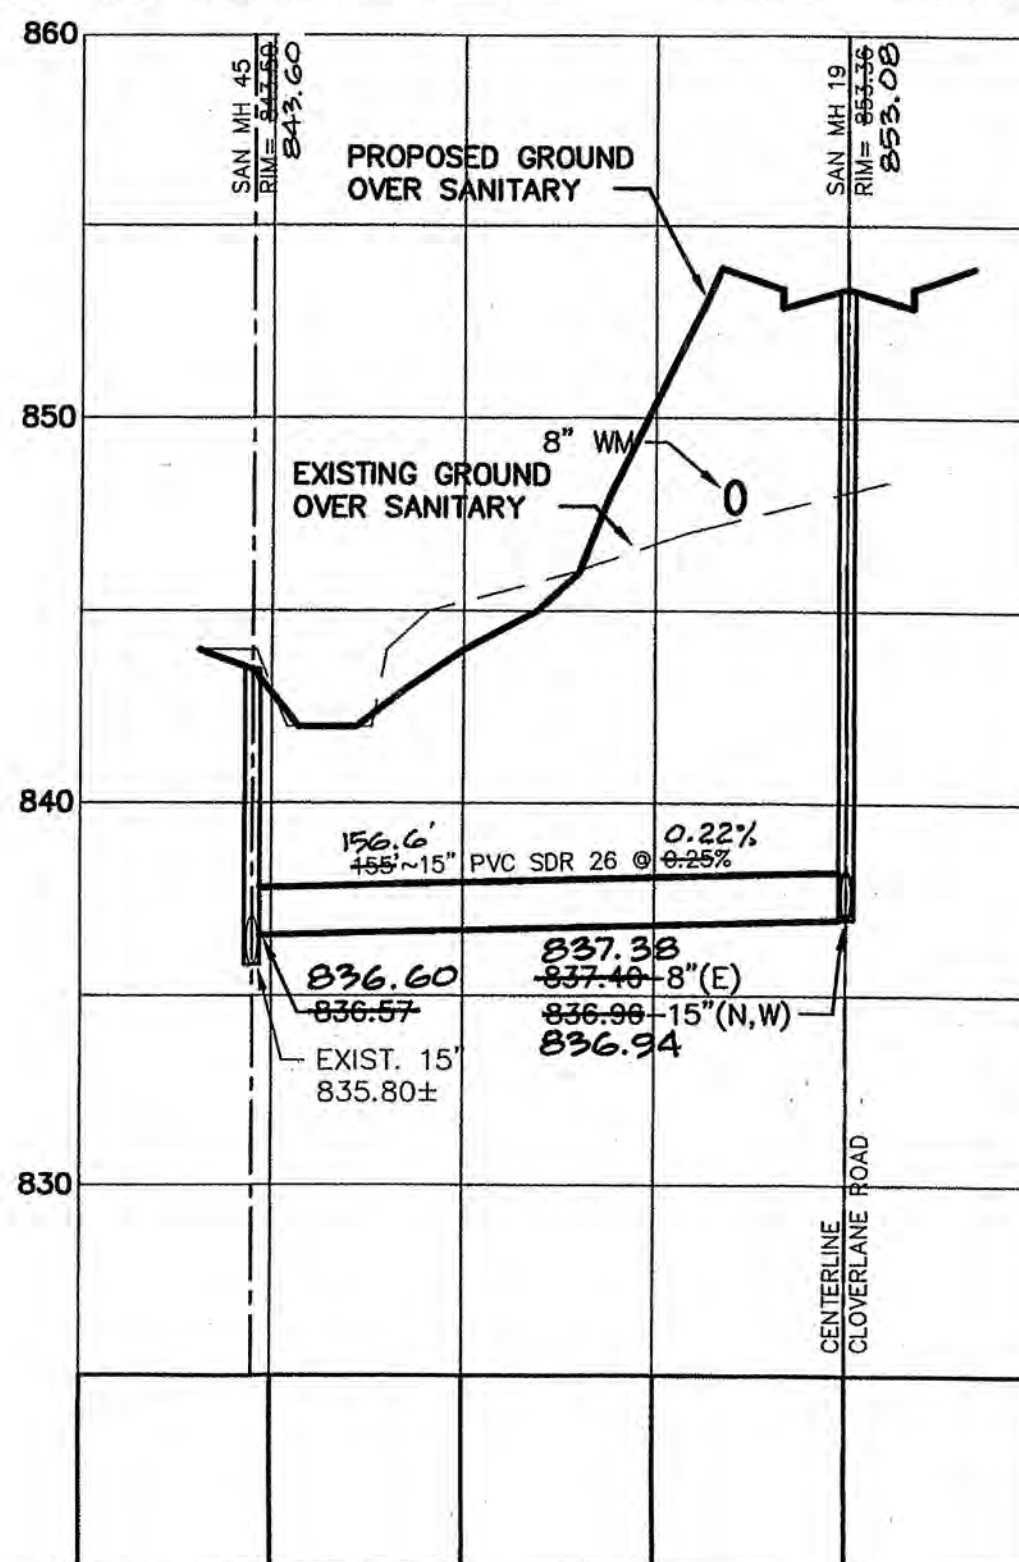

CLOVERLANE DRIVE

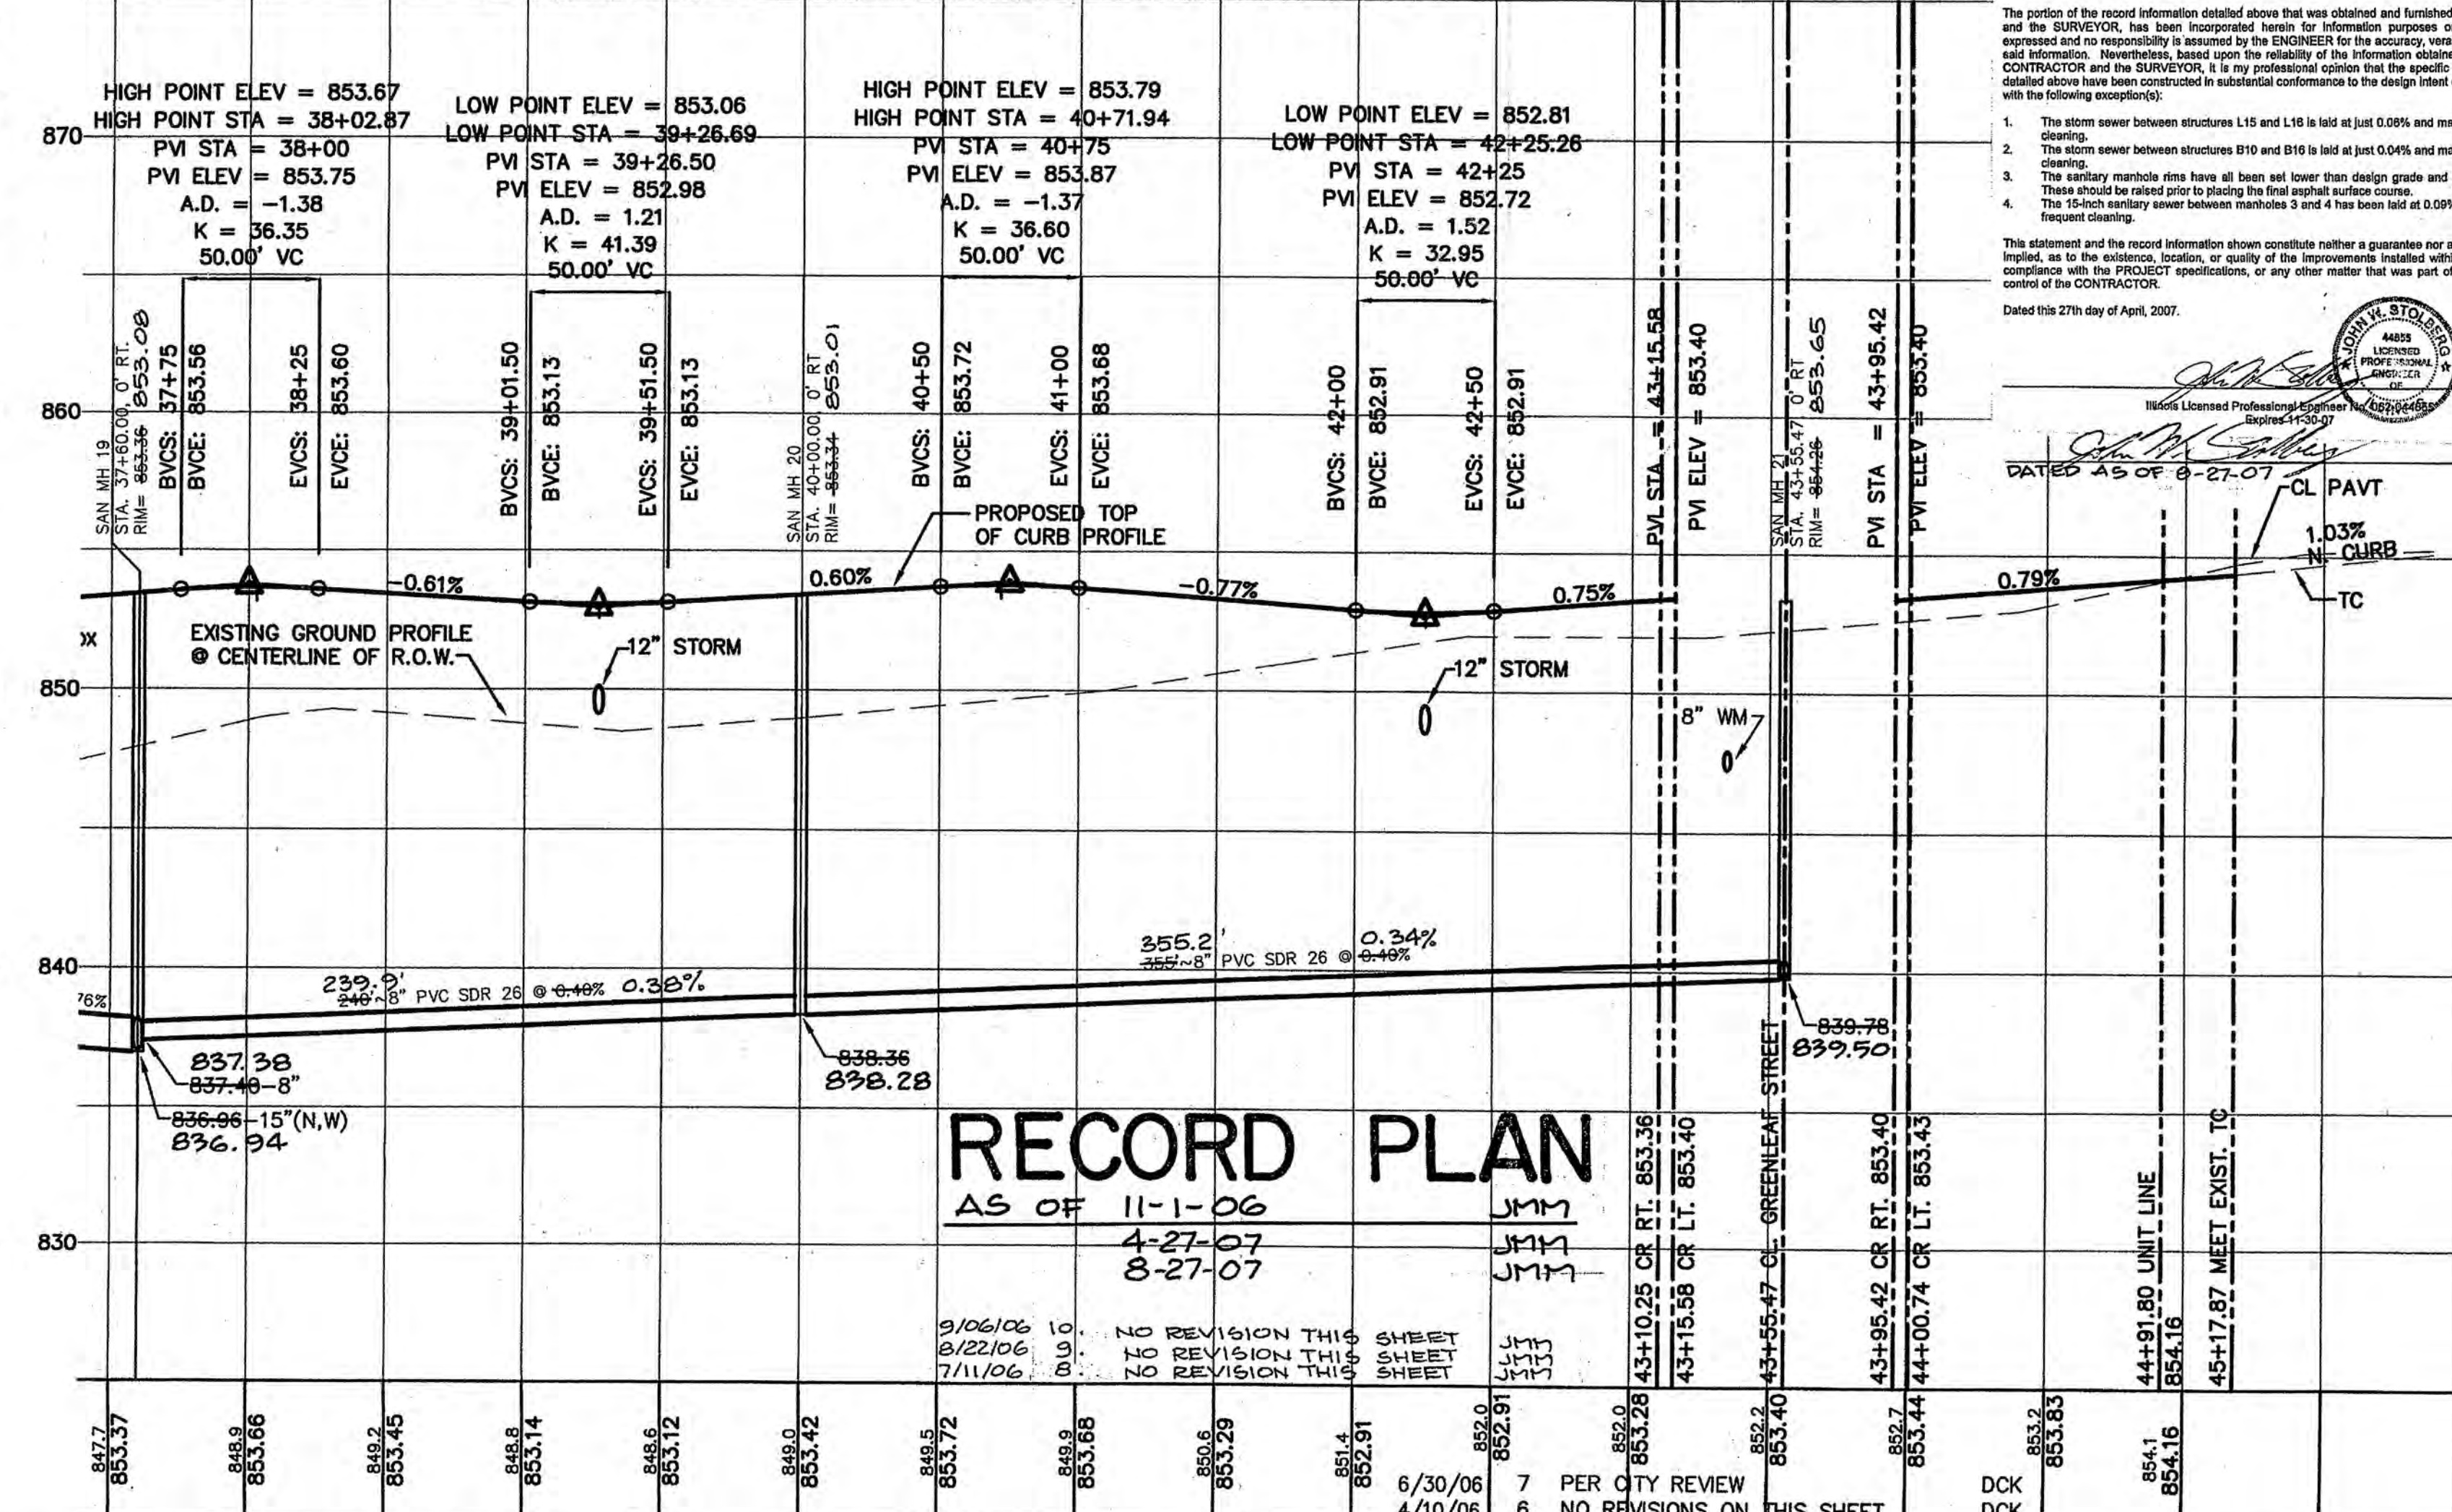

RECORD PLAN

AS OF 11-1-06
4-27-07
8-27-07

INTECH CONSULTANTS, INC.
5413 WALNUT AVE. DOWNERS GROVE, ILL.
ILLINOIS REGISTRATION NO. 184-001040

**ENGINEERS
SURVEYORS**



WISEMAN-HUGHES ENTERPRISES
975 EAST 22nd STREET
WHEATON, ILLINOIS

RESTON PONDS
UNIT 3
SYCAMORE, ILLINOIS


PLAN & PROFILE
CLOVERLANE DRIVE
Sta. 37+50.00 TO Sta. 45+17.86


2/02/06 5 PER CITY REVIEW
12/30/05 4 NO REVISIONS ON THIS SHEET
10/19/05 3 NO REVISIONS ON THIS SHEET
9/19/05 2 NO REVISIONS ON THIS SHEET
5/16/05 1 SERVICE LOCATIONS

DRAWN DCK
DESIGNED JWS/WB
SCALE HORIZ. 1" = 50'
VERT. 1" = 5'
DATE 12/15/03
SHEET 10 OF 24
PROJECT NO. 2001.029-3

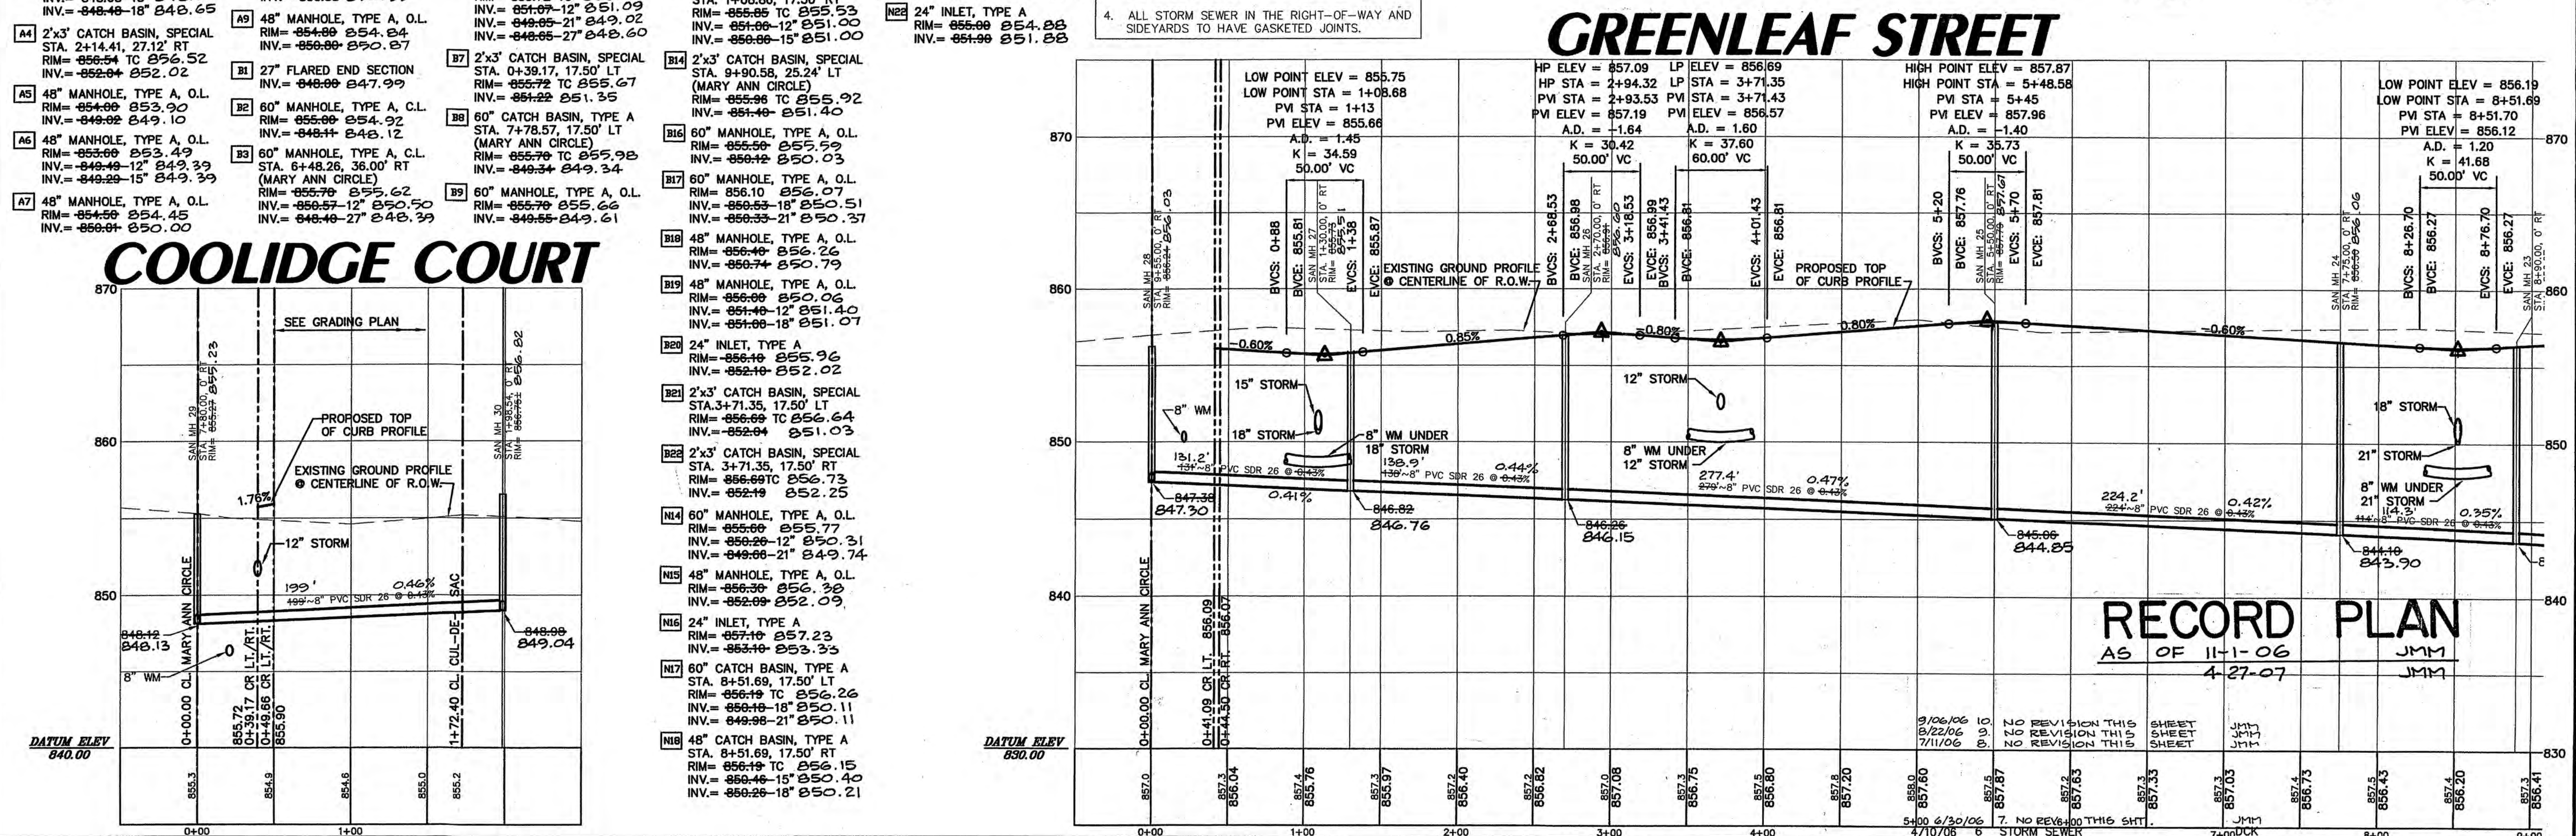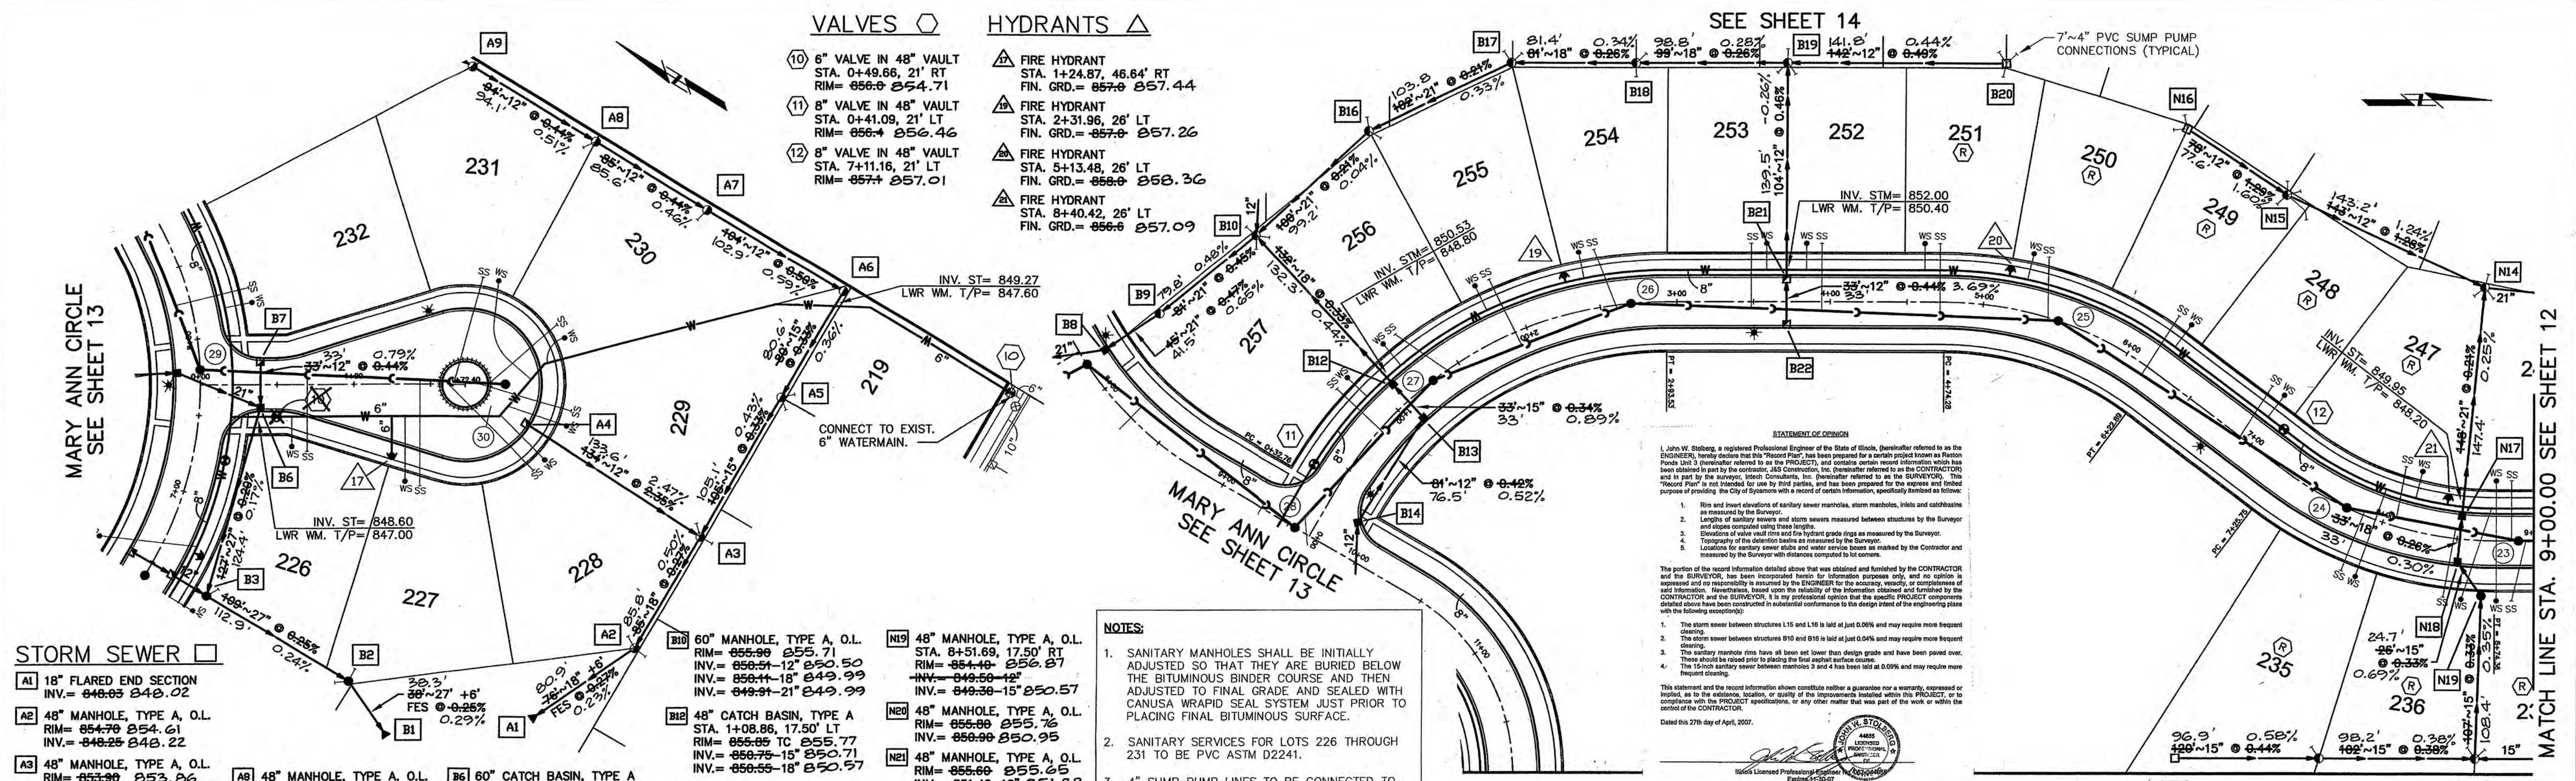


C:\Land Projects\2005\2001-029\dwg\UNIT3\2001-26\FINAL3.dwg, GREENLEAF.P12, 2/7/2006 4:08:35 PM, DCK

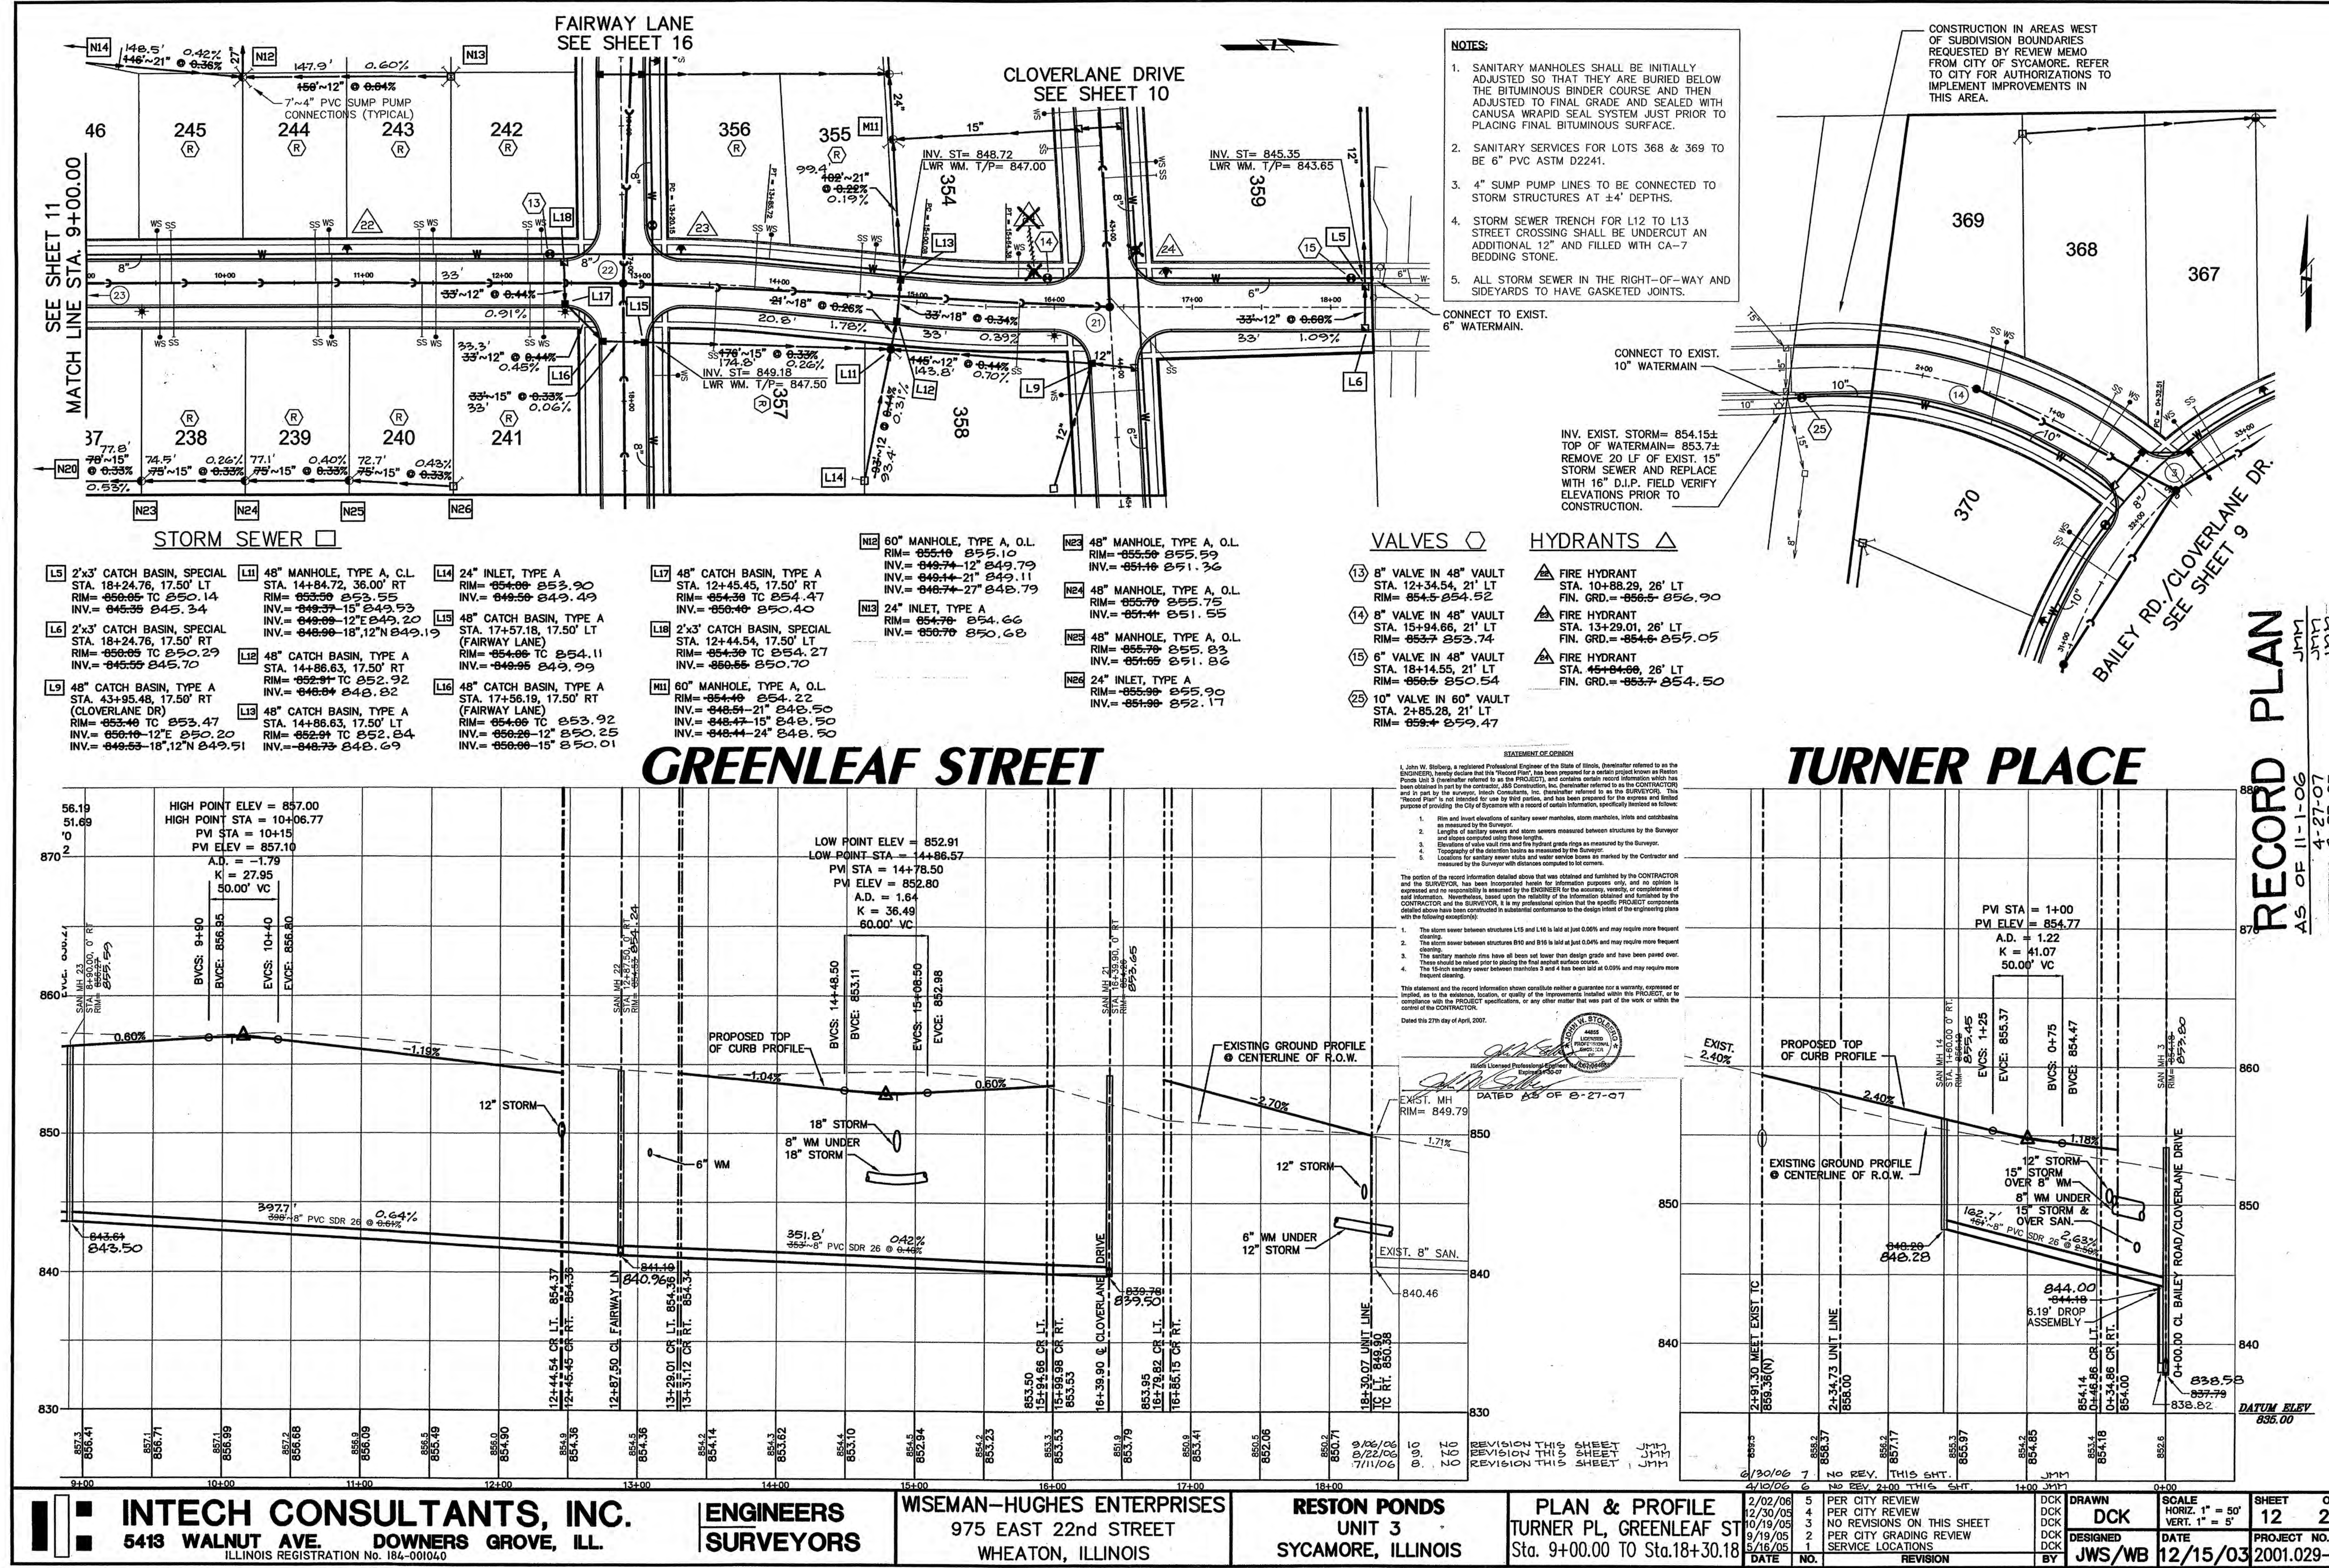

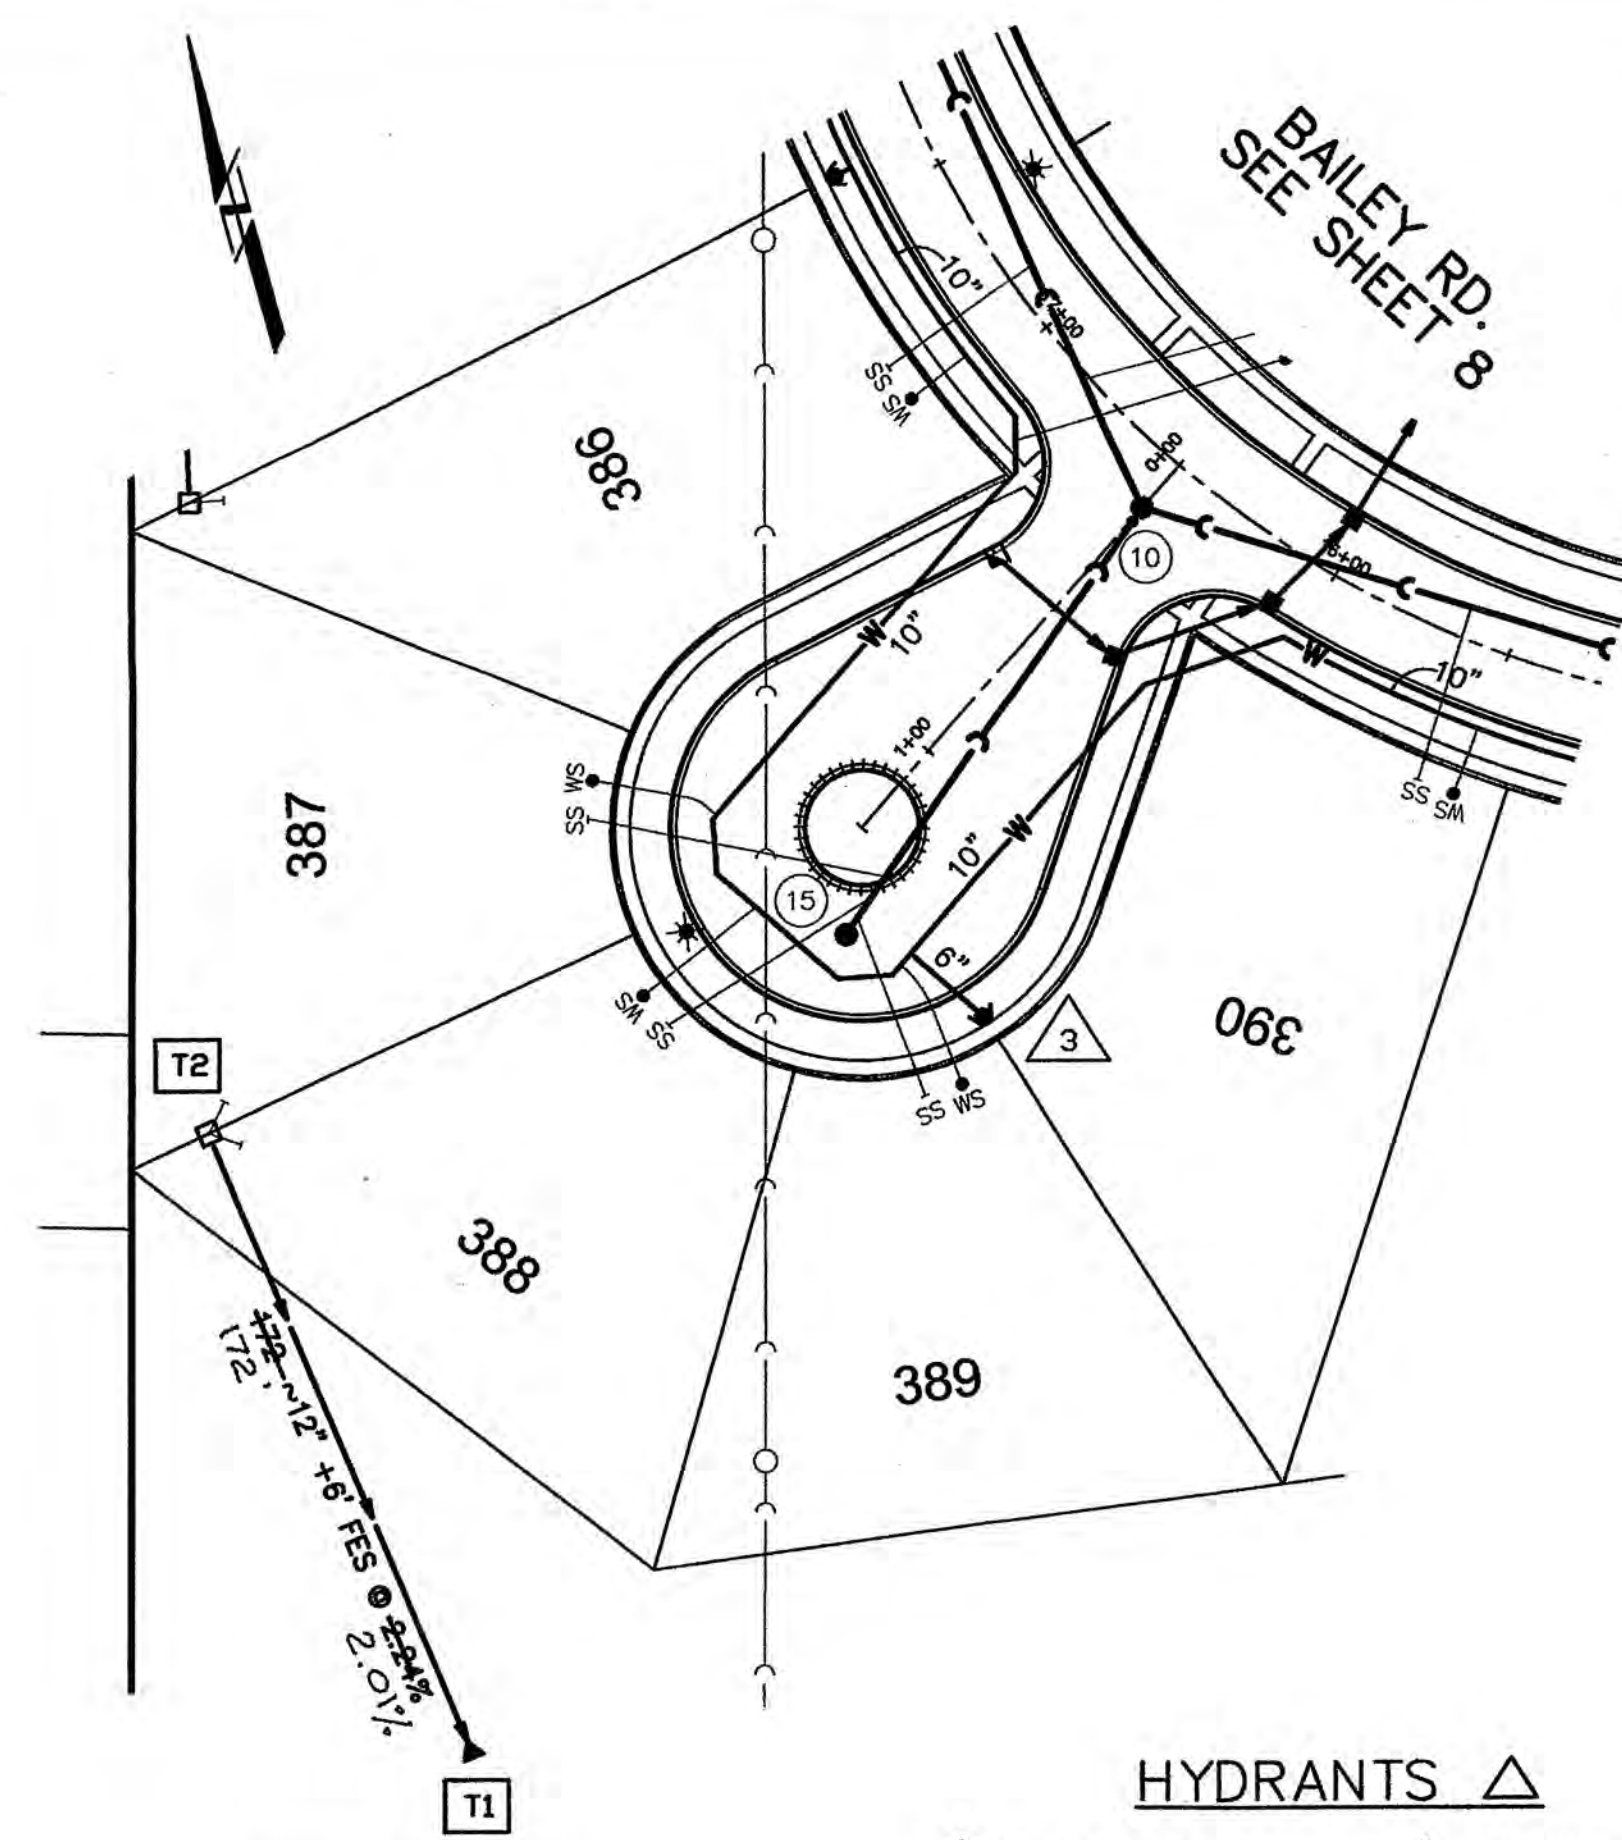

- STORM SEWER**
- A9 48" MANHOLE, TYPE A, O.L. RIM= 854.88 854.84 INV.= 856.01 850.85
 - A10 48" MANHOLE, TYPE A, O.L. RIM= 855.40 855.32 INV.= 857.21 851.22
 - A11 24" INLET, TYPE A RIM= 855.70 855.60 INV.= 857.70 851.60
 - B3 60" MANHOLE, TYPE A, C.L. STA. 6+48.26, 36.00' RT RIM= 855.70 855.62 INV.= 856.57-12' 850.50
 - B4 2'x3' CATCH BASIN, SPECIAL STA. 6+49.00, 17.50' RT RIM= 855.33 TC 855.25 INV.= 856.68 850.63
 - B5 2'x3' CATCH BASIN, SPECIAL STA. 6+49.00, 17.50' LT RIM= 855.33 TC 855.34 INV.= 856.63 850.91
 - B6 60" CATCH BASIN, TYPE A STA. 0+39.17, 17.50' RT (COOLIDGE COURT) RIM= 855.00 TC 855.77 INV.= 851.15-12' 851.09
 - B8 60" CATCH BASIN, TYPE A STA. 9+90.58, 17.50' LT RIM= 855.00 TC 855.98 INV.= 849.34 849.34
 - B14 2'x3' CATCH BASIN, SPECIAL STA. 7+78.57, 17.50' LT RIM= 855.99 TC 855.92 INV.= 851.40 851.40
 - B15 2'x3' CATCH BASIN, SPECIAL STA. 10+08.67, 17.50' RT RIM= 856.06 TC 855.97 INV.= 851.56 851.60
 - C1 12" FLARED END SECTION INV.= 848.00 848.07
 - C2 2'x3' CATCH BASIN, SPECIAL STA. 3+48.80, 17.50' RT RIM= 855.62 TC 855.56 INV.= 850.54 850.54
 - C3 2'x3' CATCH BASIN, SPECIAL STA. 3+48.80, 17.50' LT RIM= 855.62 TC 855.56 INV.= 851.12 851.04
 - D1 12" FLARED END SECTION INV.= 847.00 846.91
 - D2 2'x3' CATCH BASIN, SPECIAL STA. 1+10.00, 17.50' LT RIM= 854.26 TC 854.25 INV.= 849.74 849.70
 - D3 2'x3' CATCH BASIN, SPECIAL STA. 1+10.00, 17.50' RT RIM= 854.26 TC 854.08 INV.= 849.76 849.76
 - T1 12" FLARED END SECTION INV.= 847.56 847.64
 - T2 24" INLET, TYPE A RIM= 856.00 856.13 INV.= 851.50 851.22


- NOTES:**
- SANITARY MANHOLES SHALL BE INITIALLY ADJUSTED SO THAT THEY ARE BURIED BELOW THE BITUMINOUS BINDER COURSE AND THEN ADJUSTED TO FINAL GRADE AND SEALED WITH CANUSA WRAP SEAL SYSTEM JUST PRIOR TO PLACING FINAL BITUMINOUS SURFACE.
 - AFTER NEW 12" AND 15" SANITARY SEWER IS INSTALLED, EXISTING 12" AND 15" SANITARY SEWER SHALL BE FILLED WITH CONTROLLED LOW STRENGTH MATERIAL (FLOWABLE FILL). FRAMES AND COVERS FROM EACH OF THE EXISTING MANHOLES SHALL BE REMOVED AND MANHOLES SHALL BE FILLED WITH FLOWABLE FILL. INSTALLATION OF THE FLOWABLE FILL TO THE SATISFACTION OF THE CITY ENGINEER, SHALL BE FIELD VERIFIED.
 - SANITARY SERVICES FOR LOTS 225, 258, 259, 387, 388 & 389 TO BE 6" PVC ASTM D2241.
 - 4" SUMP PUMP LINES TO BE CONNECTED TO STORM STRUCTURES AT ±4' DEPTHS.
 - ALL STORM SEWER IN THE RIGHT-OF-WAY AND SIDEYARDS TO HAVE GASKETED JOINTS.

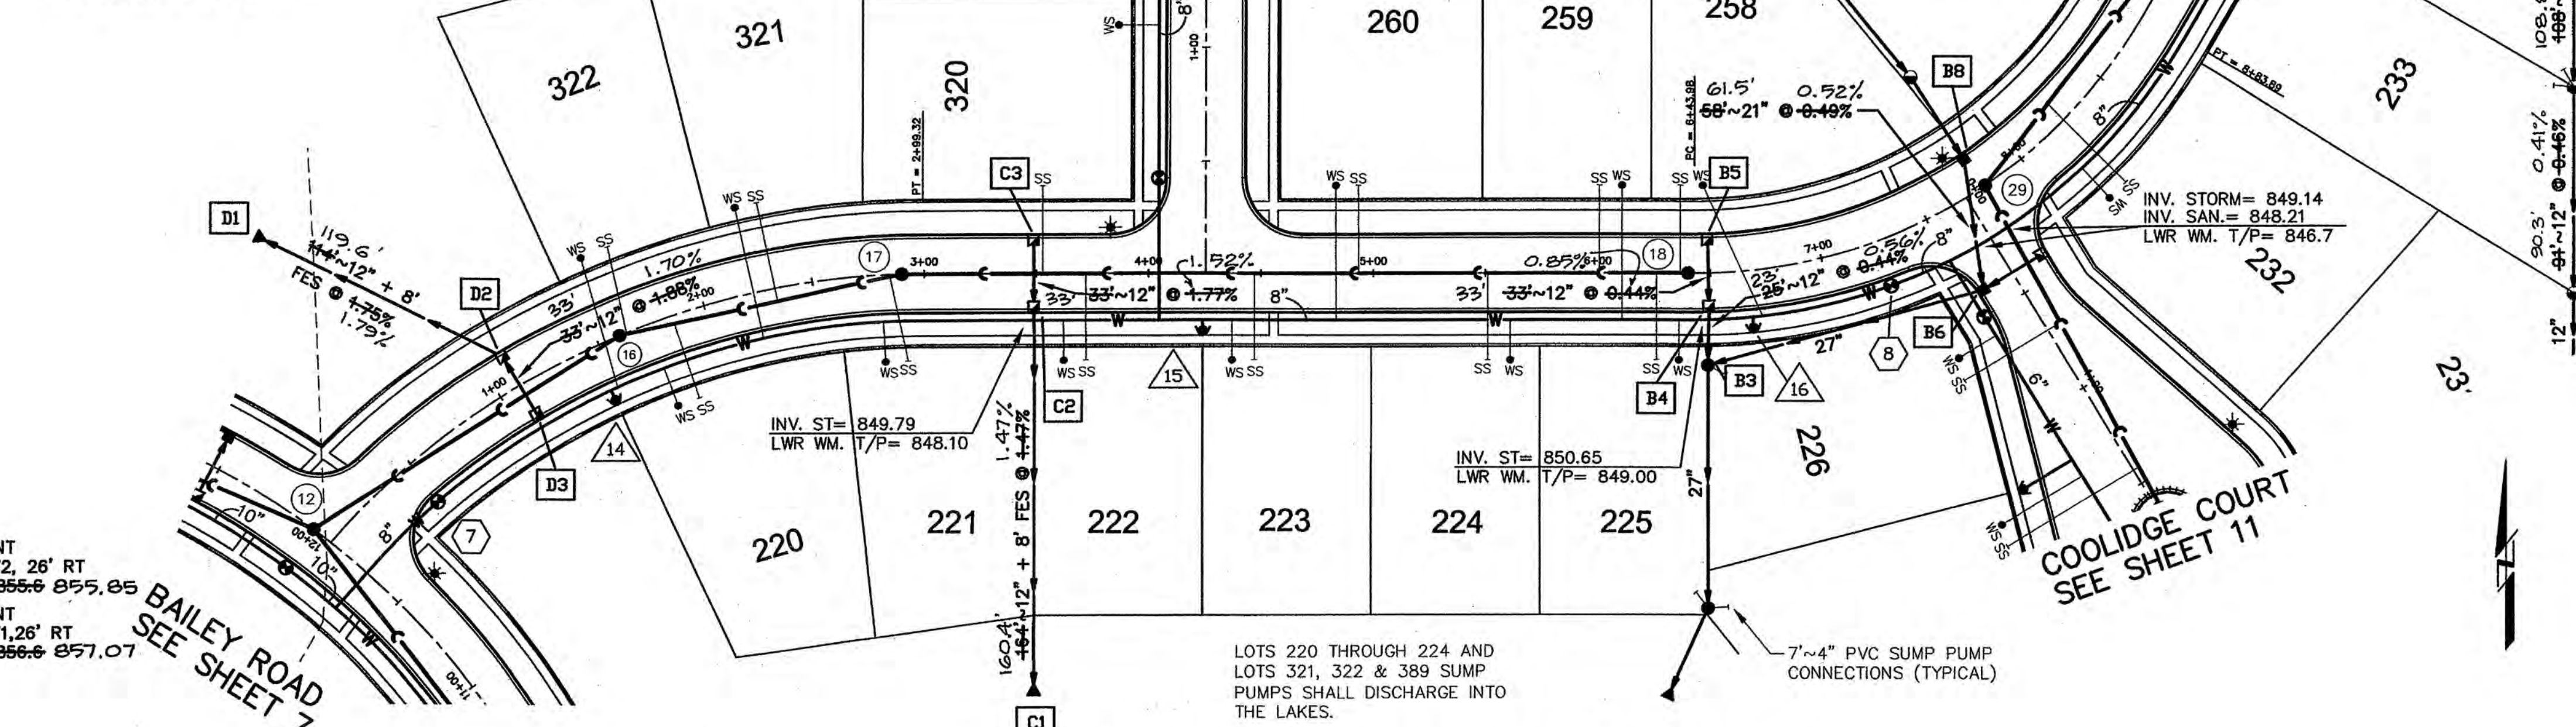


- VALVES**
- 7 8" VALVE IN 48" VAULT STA. 0+47.92, 21' RT RIM= 854.7 854.80
 - 8 8" VALVE IN 48" VAULT STA. 7+24.93, 21' RT RIM= 855.5 855.70

- HYDRANTS**
- A FIRE HYDRANT STA. 1+42.70, 56.16' LT FIN. GRD.= 856.0 857.06
 - B FIRE HYDRANT STA. 1+46.19, 26' RT FIN. GRD.= 854.8 855.09
 - C FIRE HYDRANT STA. 4+23.93, 26' RT FIN. GRD.= 855.5 855.85
 - D FIRE HYDRANT STA. 6+66.72, 26' RT FIN. GRD.= 855.6 855.85
 - E FIRE HYDRANT STA. 9+52.71, 26' RT FIN. GRD.= 856.6 857.07

LA MOIS COURT

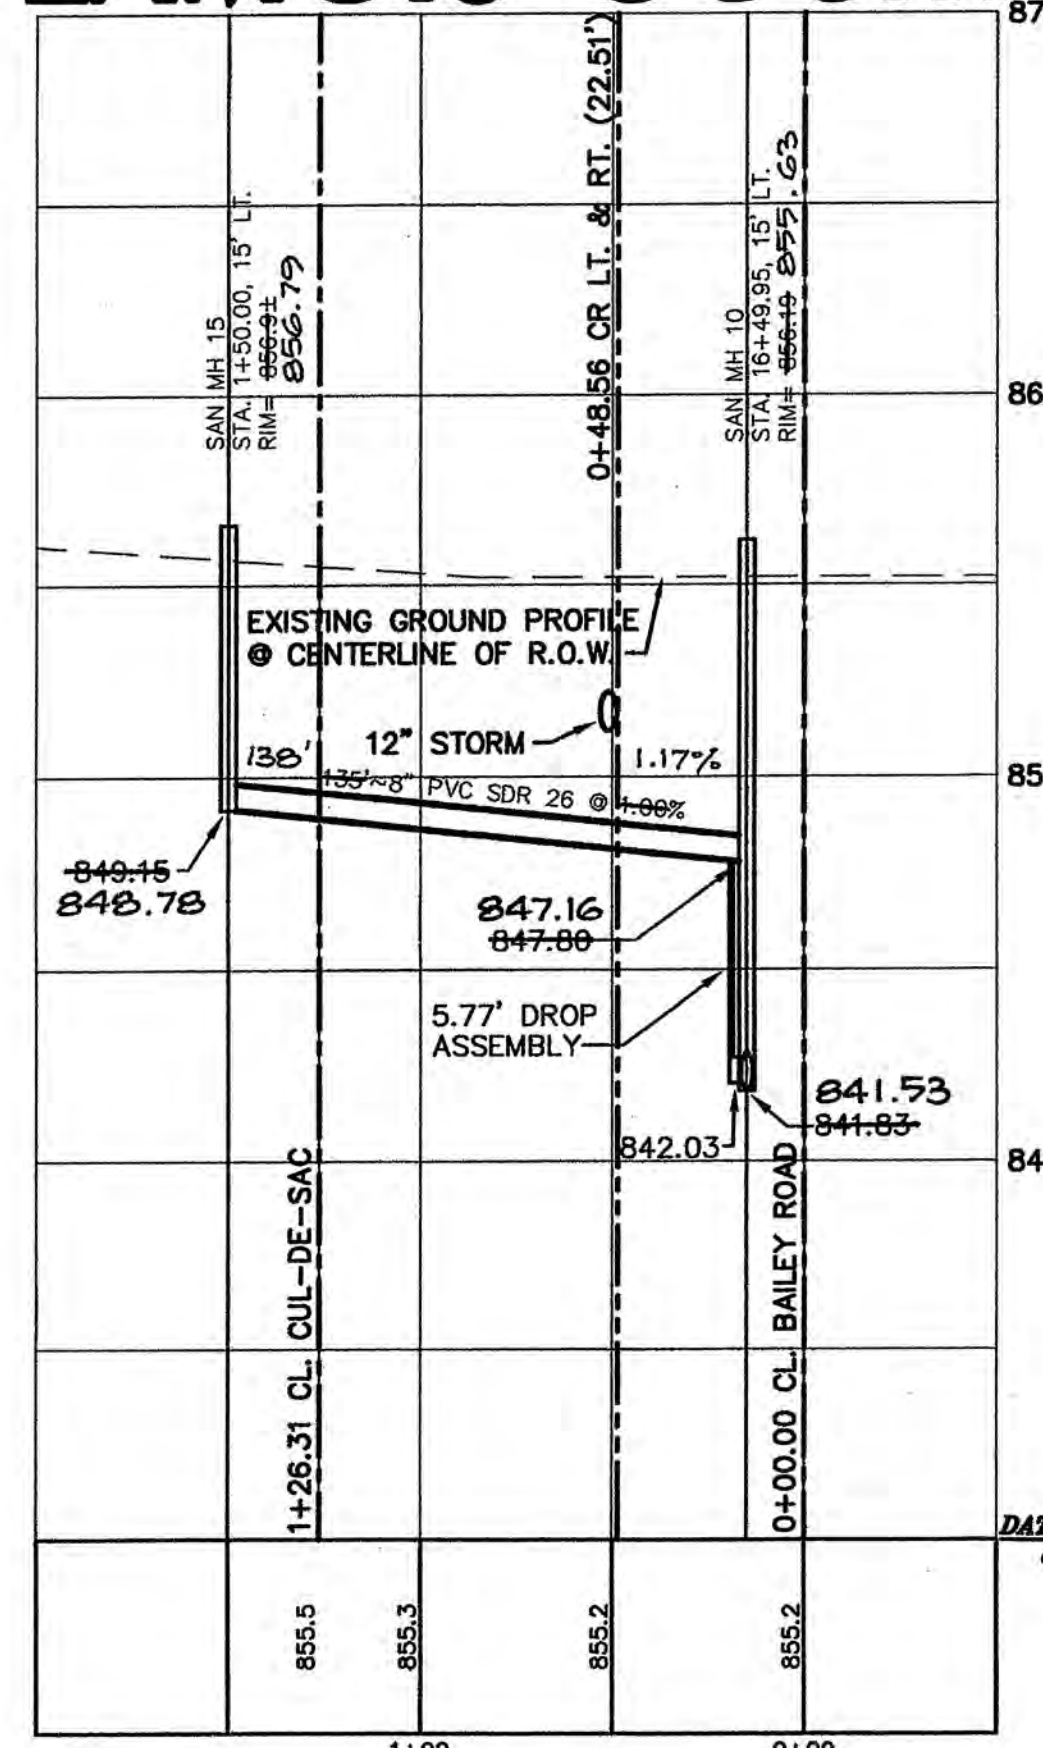

MARY ANN CIRCLE

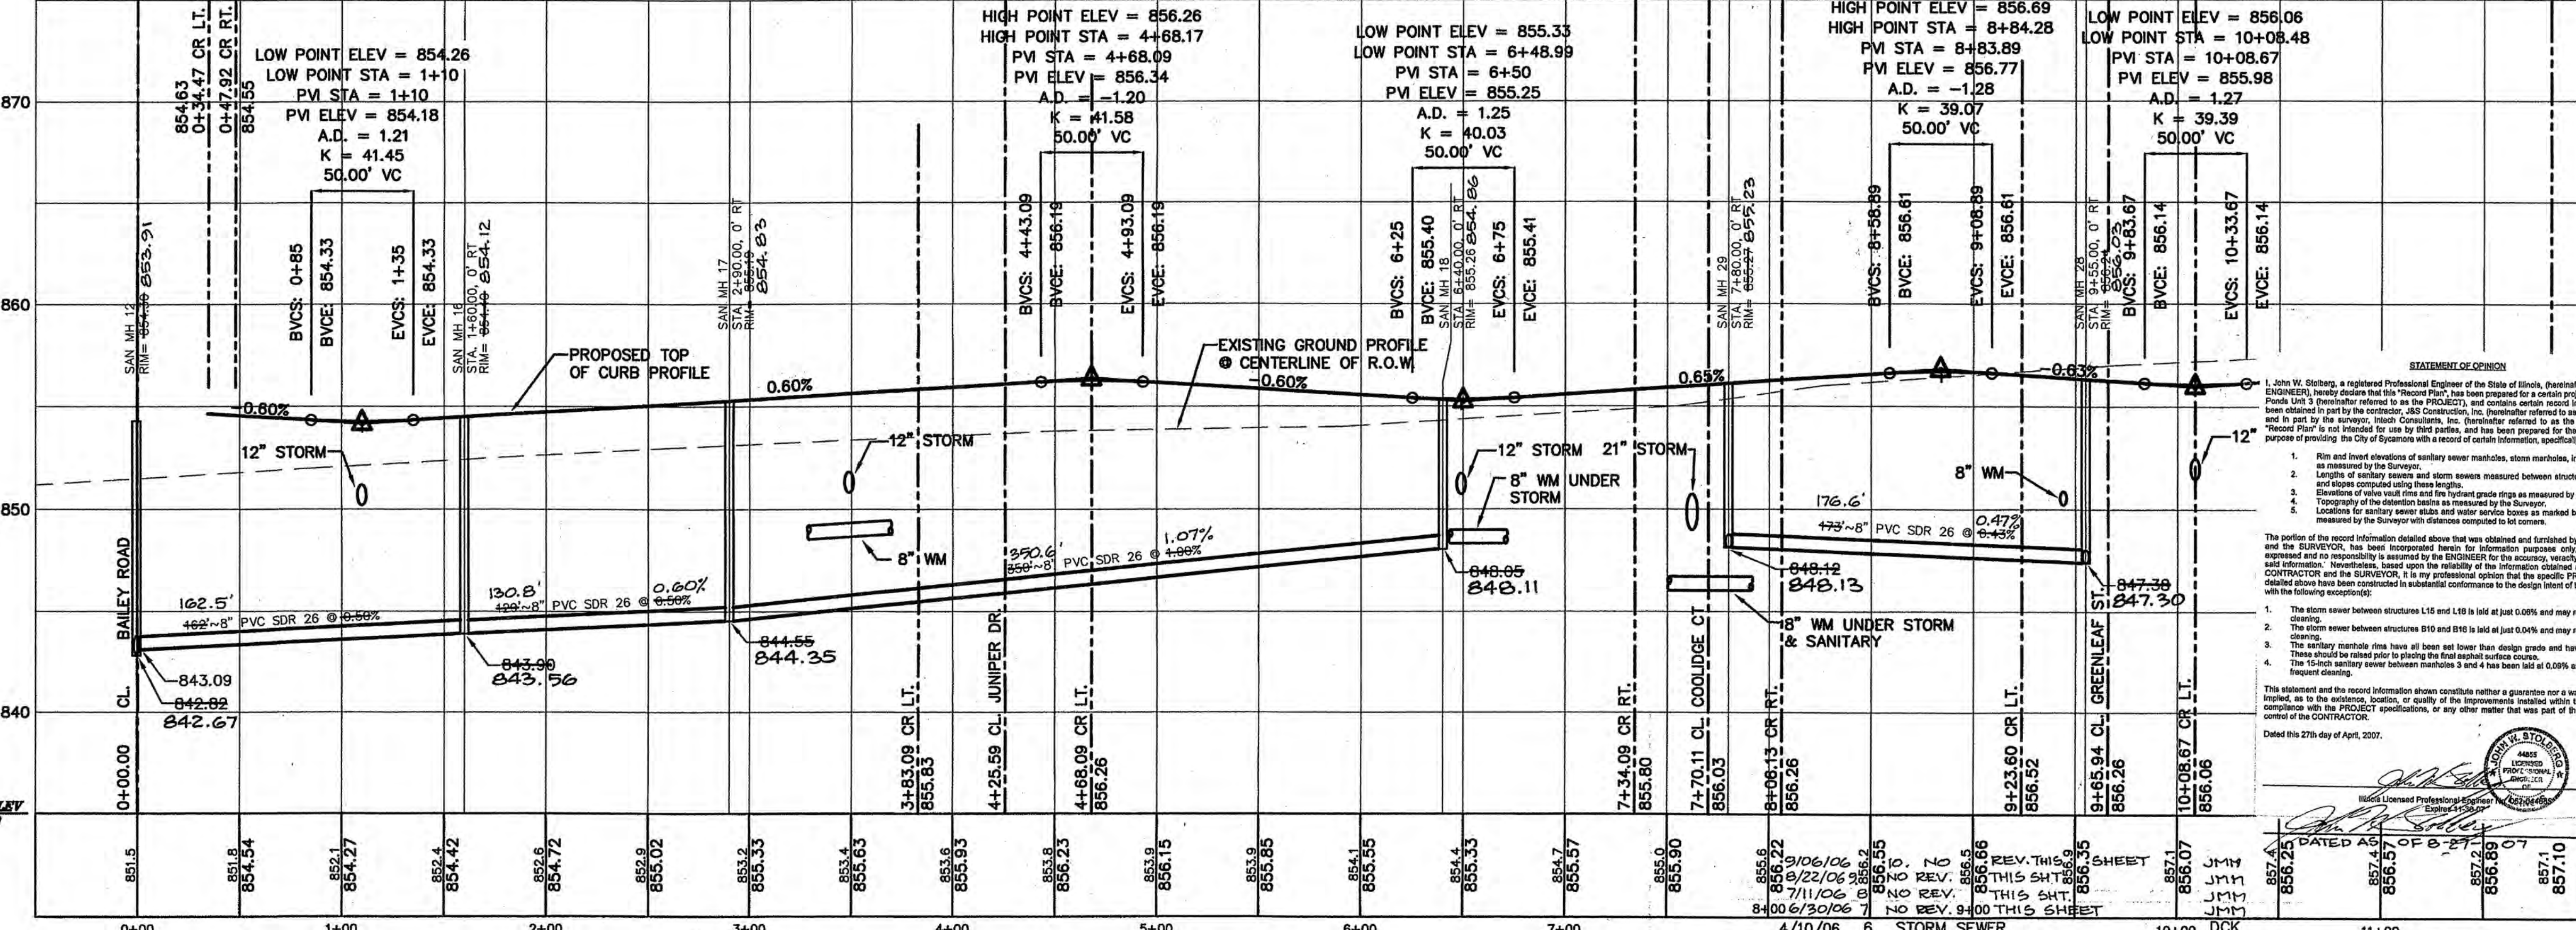

STATEMENT OF OPINION


I, John W. Stetson, a registered Professional Engineer of the State of Illinois, have prepared this "Record Plan" for the project known as "Reston Ponds, Unit 3" (hereinafter referred to as the "PROJECT"), and I hereby certify that the information contained herein was obtained in part by the contractor, JWS Construction, Inc. (hereinafter referred to as the "CONTRACTOR") and in part by the engineer, John Stetson, Inc. (hereinafter referred to as the "ENGINEER"). This "Record Plan" is not intended to be used for any other purpose than the design and construction of the PROJECT and the ENGINEER shall not be responsible for any errors or omissions in the design or construction of the PROJECT.

The portion of the record information detailed above that was obtained and furnished by the CONTRACTOR and the ENGINEER, has been incorporated herein for information purposes only, and no opinion is expressed and no responsibility is assumed by the ENGINEER for the accuracy, reliability, or completeness of said information. Nevertheless, based upon the reliability of the information obtained and furnished by the CONTRACTOR and the ENGINEER, it is my professional opinion that the PROJECT complies with the design and construction of the PROJECT as detailed above has been constructed in substantial conformance to the design intent of the engineering plans with the following exceptions:


- The storm sewer between structures L15 and L16 is laid at just 0.00% and may require more frequent clearing.
- The storm sewer between structures B10 and B11 is laid at just 0.04% and may require more frequent clearing.
- The sanitary manhole riser has all been set lower than design grade and have been paved over.
- The 15-inch sanitary sewer between manholes 3 and 4 has been laid at 0.00% and may require more frequent clearing.

This statement and the record information shown constitute neither a guarantee nor a warranty, expressed or implied, as to the existence, location, or quality of the improvements contained within this PROJECT, or to compliance with the PROJECT specifications, or any other matter that was part of the work or within the control of the CONTRACTOR.


Dated this 27th day of April, 2007.

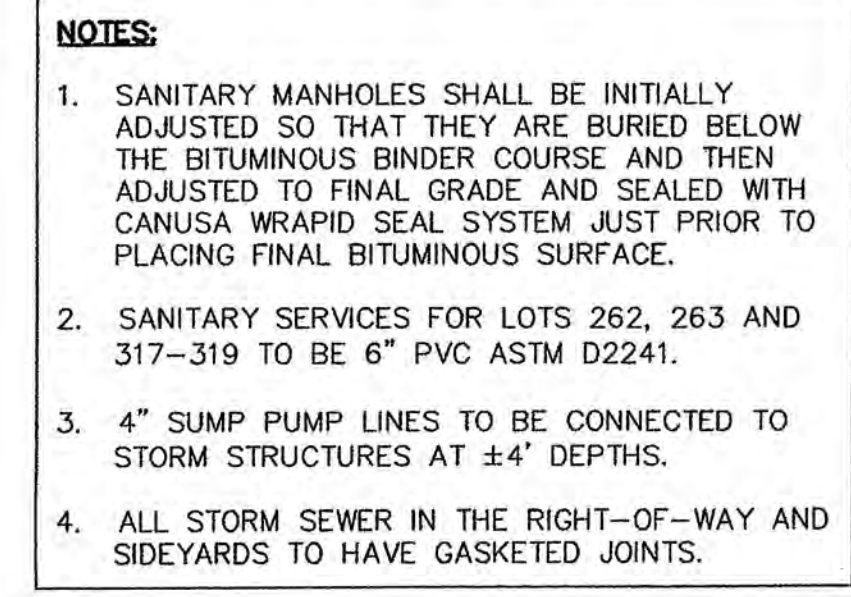

857.32			LP ELEV = 855.80		
+94.84			LP STA = 7+68.54		

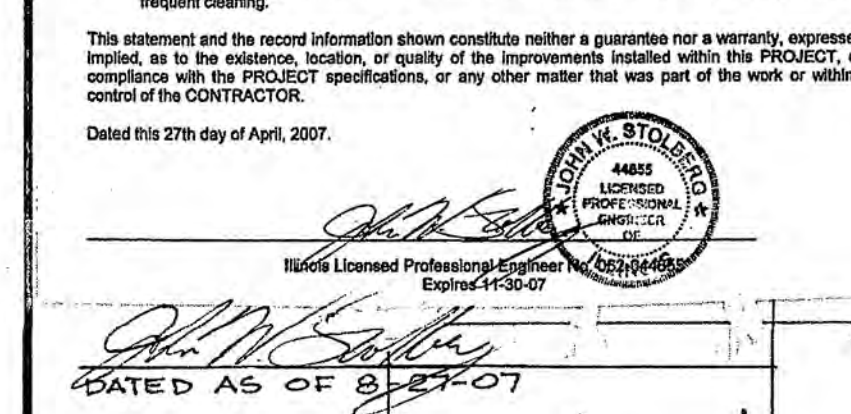

 INTECH CONSULTANTS, INC. 5413 WALNUT AVE. DOWNERS GROVE, ILL. ILLINOIS REGISTRATION No. 184-001040	ENGINEERS SURVEYORS	WISEMAN-HUGHES ENTERPRISES 975 EAST 22nd STREET WHEATON, ILLINOIS	RESTON PONDS UNIT 3 SYCAMORE, ILLINOIS	PLAN & PROFILE JUNIPER DRIVE Sta. 0+00.00 TO Sta. 14+18.01	2/02/06 5 PER CITY REVIEW 12/30/05 4 PER CITY REVIEW 10/19/05 3 NO REVISIONS ON THIS SHEET 9/19/05 2 NO REVISIONS ON THIS SHEET 5/16/05 1 SERVICE LOCATIONS	DCK DCK DCK DESIGNED BY JWS/WB	SCALE HORIZ. 1" = 50' VERT. 1" = 5' DATE 12/15/03	SHEET OF 14 24 PROJECT NO. 2001.029-3
					DATE NO. REVISION	DCK DCK DCK	13+00 13+10 13+20 13+30 13+40	

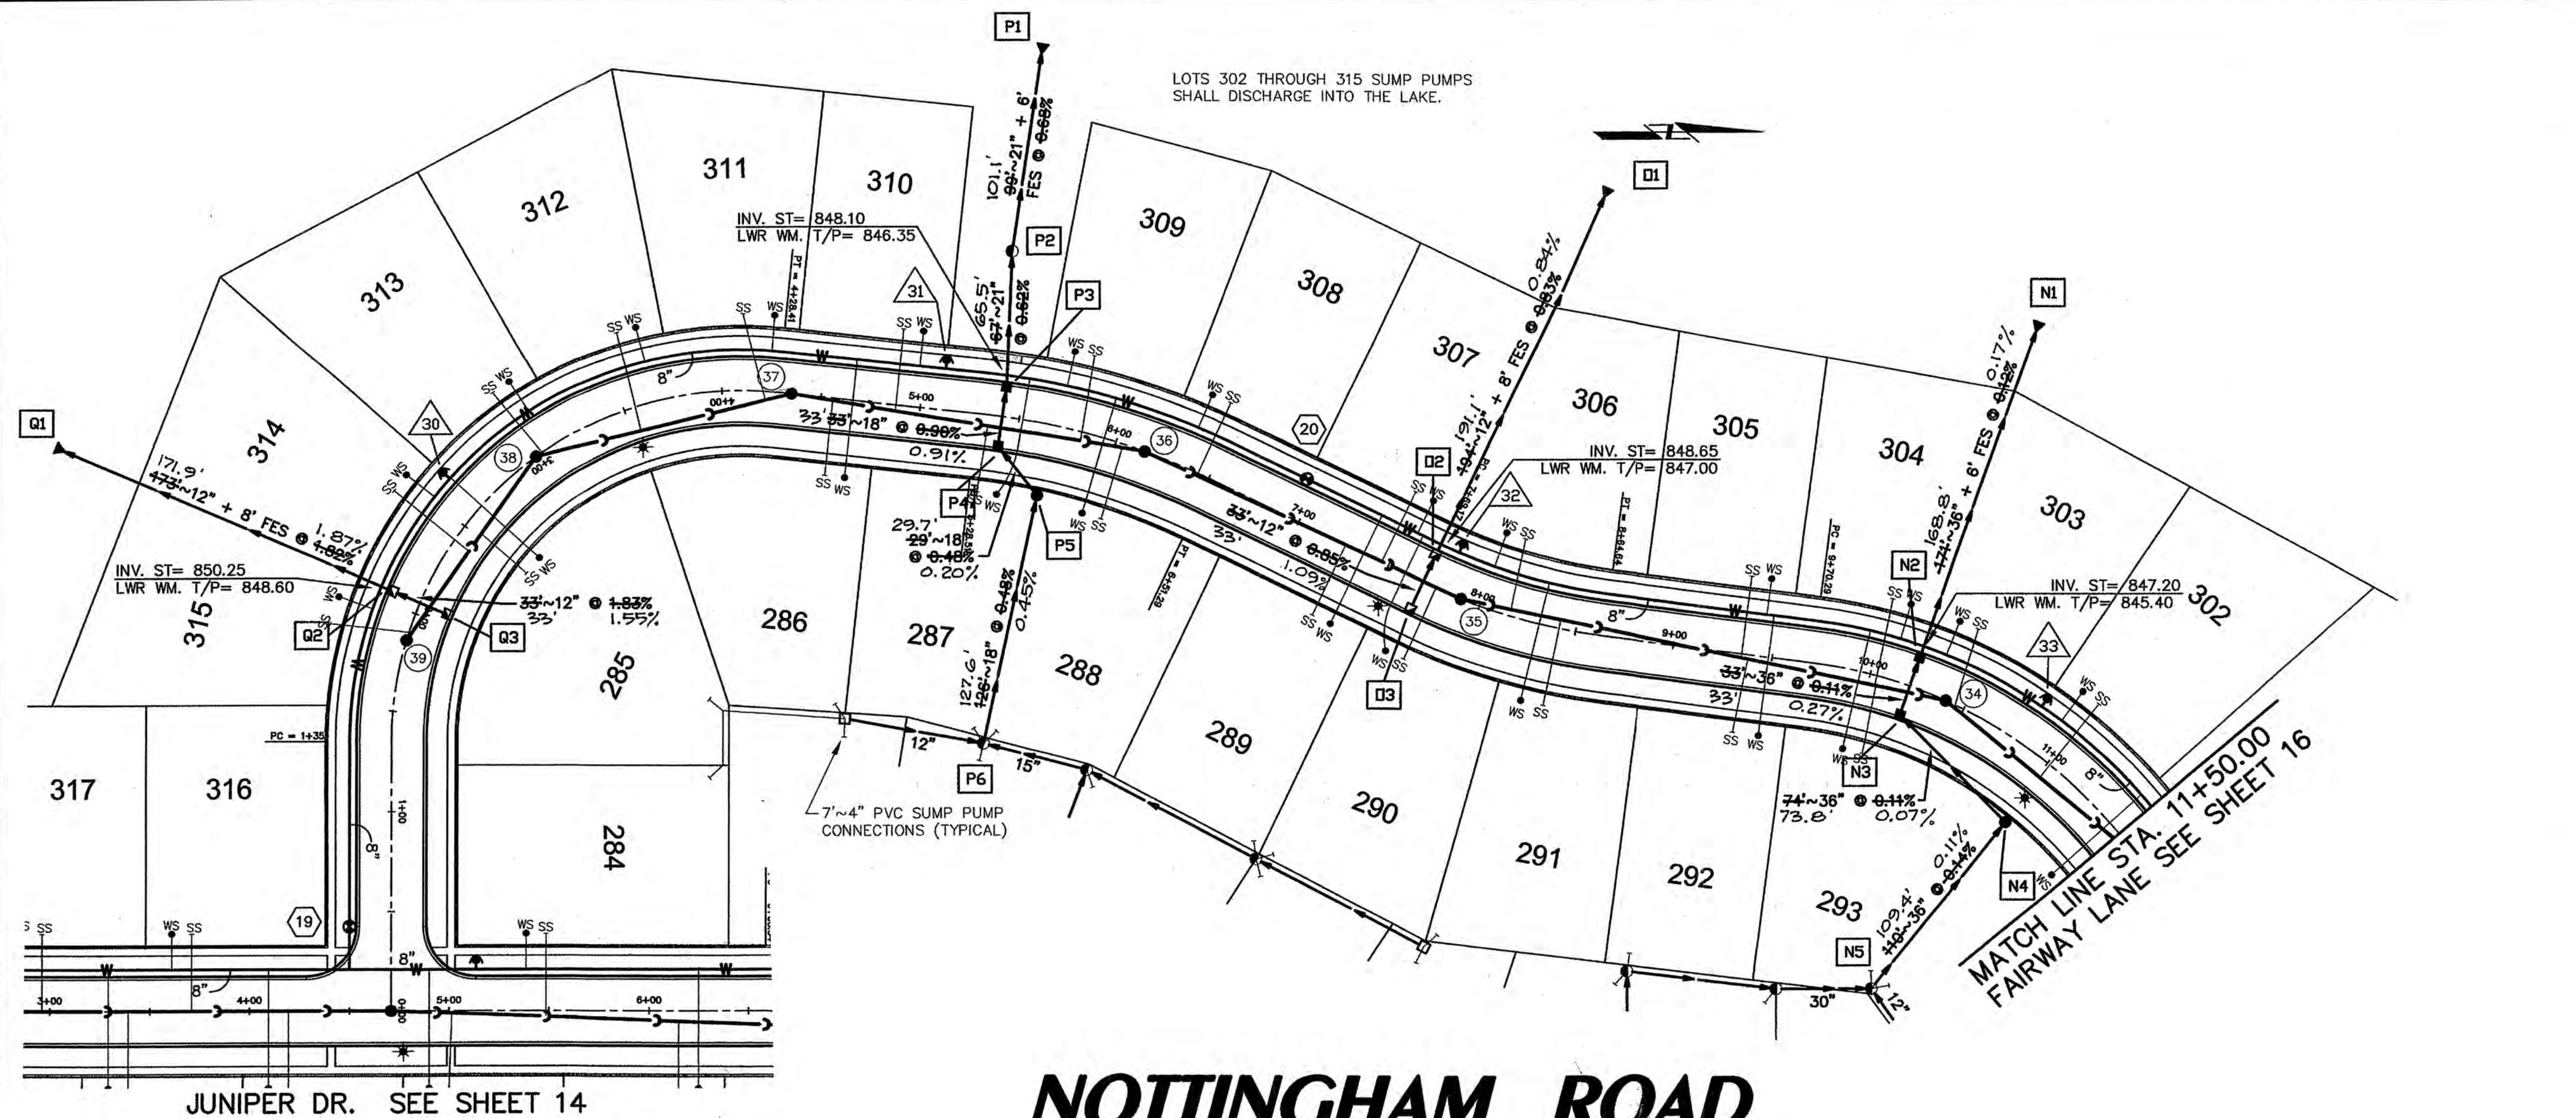

STORM SEWER □

N1 36" FLARED END SECTION INV. = 847.00 846.91	P1 21" FLARED END SECTION INV. = 847.00 846.94
N2 60" CATCH BASIN, TYPE A STA. 10+20.98, 17.50' LT RIM = 853.30 TC 853.35 INV. = 847.21 847.21	P2 60" MANHOLE, TYPE A, O.L. RIM = 852.50 852.50 INV. = 847.70
N3 72" CATCH BASIN, TYPE A STA. 10+20.98, 17.50' RT RIM = 853.30 TC 853.41 INV. = 847.25 847.30	P3 48" CATCH BASIN, TYPE A STA. 5+41.37, 17.50' LT RIM = 853.03 TC 852.86 INV. = 846.32 846.40 INV. = 846.12 21" 846.15
N4 72" MANHOLE, TYPE A, C.L. STA. 11+01.62, 36.00' RT RIM = 854.40 854.40 INV. = 847.33 847.35	P4 48" CATCH BASIN, TYPE A STA. 5+41.37, 17.50' RT RIM = 853.03 TC 852.93 INV. = 846.62 846.70
N5 60" MANHOLE, TYPE A, O.L. RIM = 855.50 855.35 INV. = 849.08 12" 849.15 INV. = 847.88 30" 847.84 INV. = 847.48 36" 847.47	P5 48" MANHOLE, TYPE A, C.L. STA. 5+66.82, 36.00' RT RIM = 853.70 853.62 INV. = 848.75 848.76
D1 12" FLARED END SECTION INV. = 847.00 846.95	P6 48" MANHOLE, TYPE A, O.L. RIM = 854.40 854.24 INV. = 849.30 12" 849.30 INV. = 849.56 15" 849.51 INV. = 849.30 18" 849.34
D2 2'x3' CATCH BASIN, SPECIAL STA. 7+68.97, 17.50' LT RIM = 853.40 TC 853.49 INV. = 848.60 848.63	Q1 12" FLARED END SECTION INV. = 847.00 846.94
D3 2'x3' CATCH BASIN, SPECIAL STA. 7+68.97, 17.50' RT RIM = 853.40 TC 853.34 INV. = 848.60 848.99	Q2 2'x3' CATCH BASIN, SPECIAL STA. 2+05.70, 17.50' LT RIM = 855.40 TC 855.17 INV. = 850.30 850.30
	Q3 2'x3' CATCH BASIN, SPECIAL STA. 2+05.70, 17.50' RT RIM = 855.40 TC 855.40 INV. = 850.30 850.81


VALVES □

- 19 8" VALVE IN 48" VAULT
STA. 0+42.50, 21' LT
RIM = 856.7 856.67
- 20 8" VALVE IN 48" VAULT
STA. 6+94.17, 21' LT
RIM = 854.0 854.05

HYDRANTS △

- △ FIRE HYDRANT
STA. 2+62.76, 26' LT
FIN. GRD. = 855.3 855.59
- △ FIRE HYDRANT
STA. 5+10.69, 26' LT
FIN. GRD. = 853.6 853.70
- △ FIRE HYDRANT
STA. 7+80.12, 26' LT
FIN. GRD. = 853.0 853.29
- △ FIRE HYDRANT
STA. 10+81.75, 26' LT
FIN. GRD. = 854.4 854.49

NOTTINGHAM ROAD

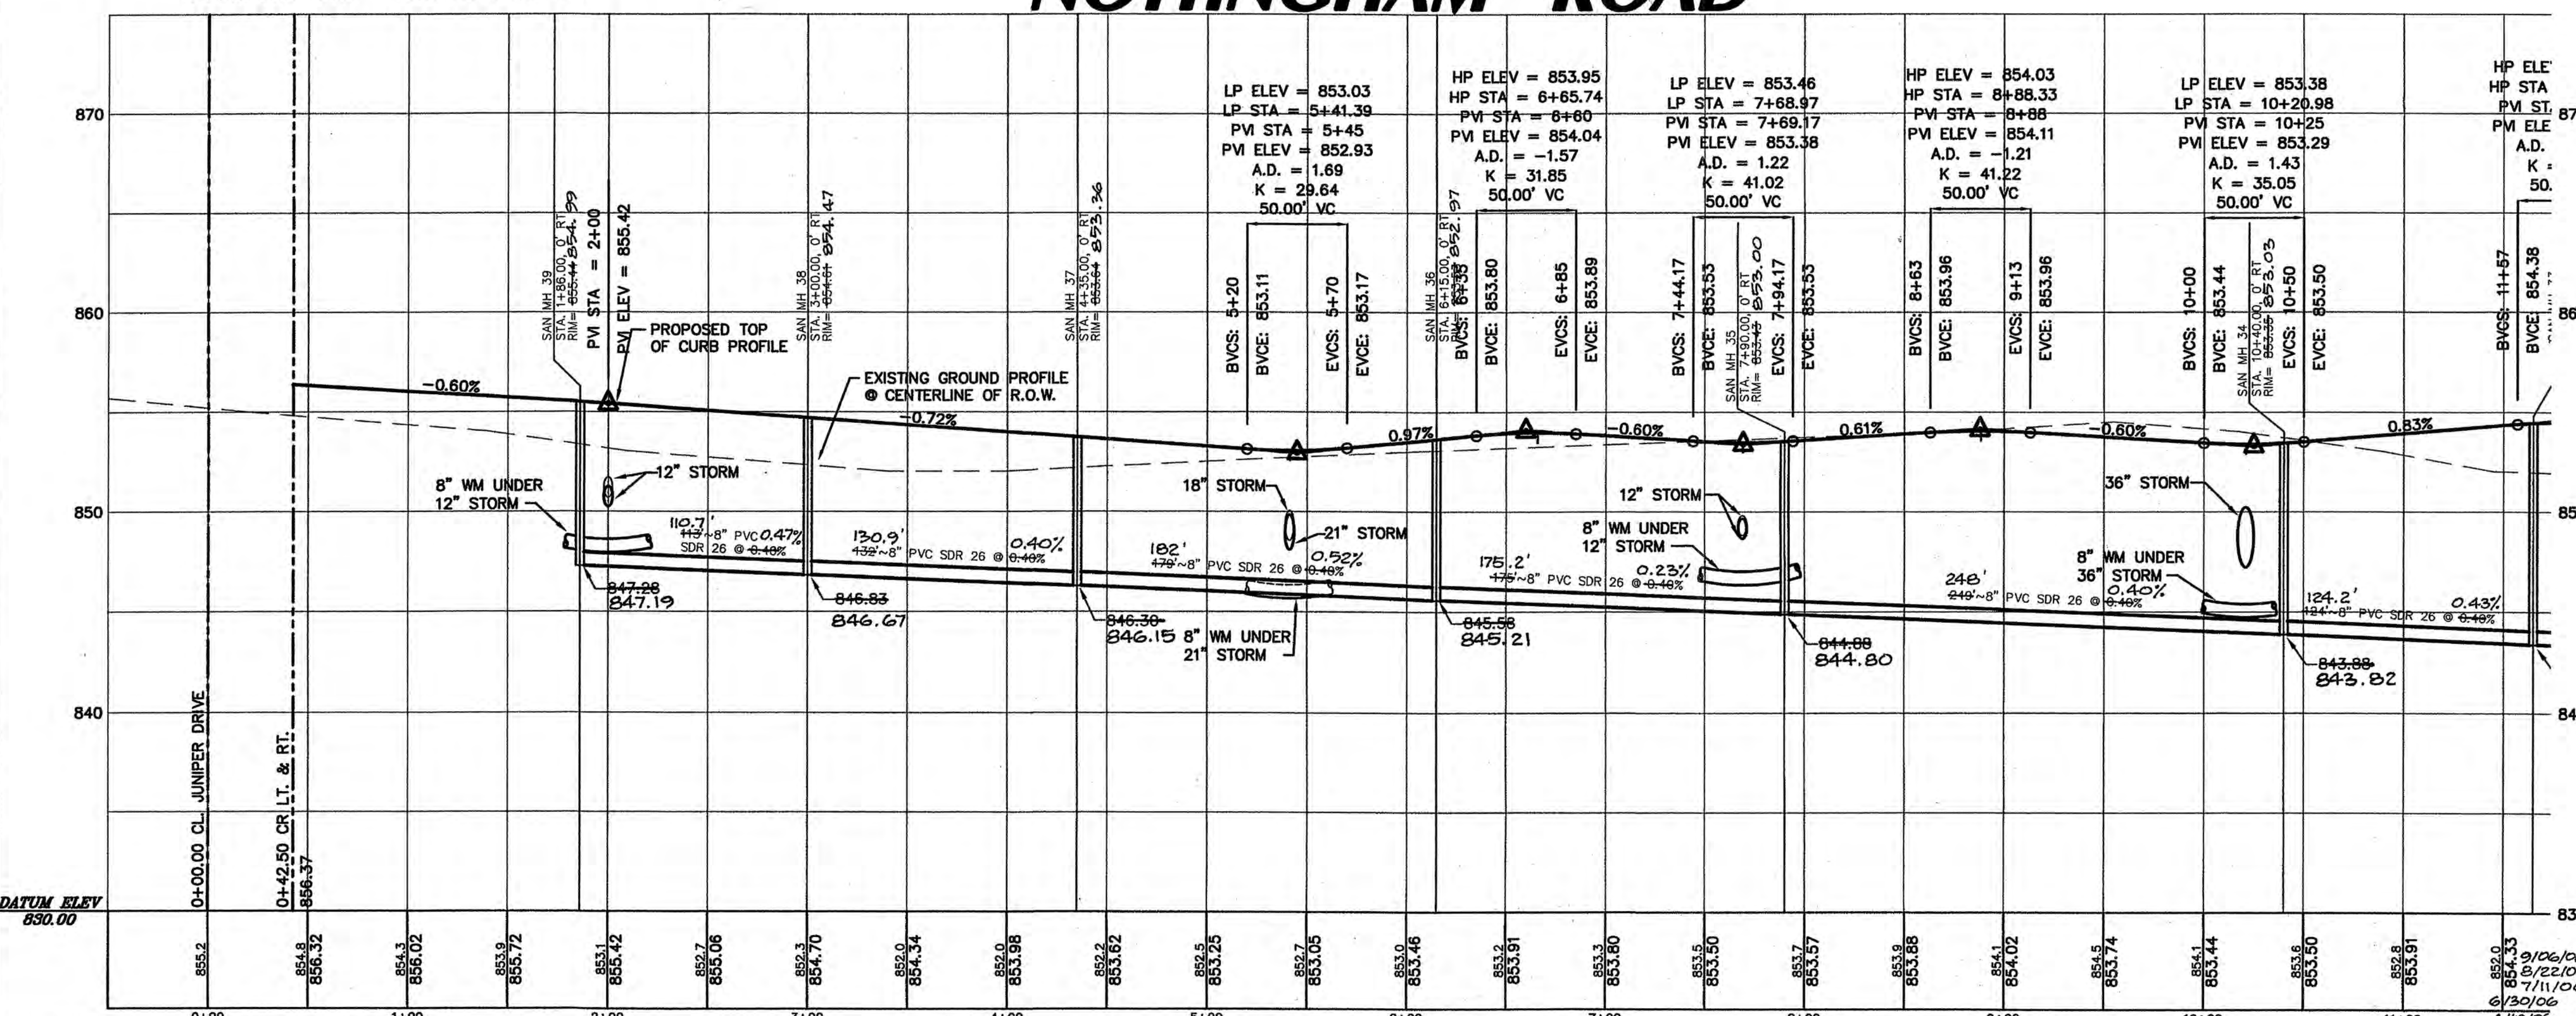

NOTES:

- SANITARY MANHOLES SHALL BE INITIALLY ADJUSTED SO THAT THEY ARE BURIED BELOW THE BITUMINOUS BINDER COURSE AND THEN ADJUSTED TO FINAL GRADE AND SEALED WITH CANUSA WRAPID SEAL SYSTEM JUST PRIOR TO PLACING FINAL BITUMINOUS SURFACE.
- SANITARY SERVICES FOR LOTS 285-288 AND 309-315 TO BE 6" PVC ASTM D2241.
- 4" SUMP PUMP LINES TO BE CONNECTED TO STORM STRUCTURES AT ±4' DEPTHS.
- ALL STORM SEWER IN THE RIGHT-OF-WAY AND SIDEYARDS TO HAVE GASKETED JOINTS.

STATEMENT OF OPINION

I, John W. Stolberg, a registered Professional Engineer of the State of Illinois, (hereinafter referred to as the ENGINEER), hereby declare that this "Record Plan", has been prepared for a certain project known as Reston Ponds Unit 3 (hereinafter referred to as the PROJECT), and contains certain record information which has been obtained in part by the CONTRACTOR, JWS Construction, Inc. (hereinafter referred to as the CONTRACTOR), and in part by the SURVEYOR, Intech Consultants, Inc. (hereinafter referred to as the SURVEYOR). This "Record Plan" is not intended for use by third parties, and has been prepared for the express and limited purpose of providing the City of Sycamore with a record of certain information, specifically itemized as follows:

- Rim and invert elevations of sanitary sewer manholes, storm manholes, inlets and catchbasins as measured by the Surveyor.
- Lengths of sanitary sewers and storm sewers measured between structures by the Surveyor and slopes computed using these lengths.
- Elevations of valve vault rims and fire hydrant grade rings as measured by the Surveyor.
- Topography of the detention basins as measured by the Surveyor.
- Locations for sanitary sewer stubs and water service lines as marked by the Contractor and measured by the Surveyor with distances computed to lot corners.

The portion of the record information detailed above that was obtained and furnished by the CONTRACTOR and the SURVEYOR, has been incorporated herein for information purposes only, and no opinion is expressed and no responsibility is assumed by the ENGINEER for the accuracy, validity, or completeness of said information. Nevertheless, based upon the reliability of the information obtained and furnished by the CONTRACTOR and the SURVEYOR, it is my professional opinion that the specific PROJECT components detailed above have been constructed in substantial conformance to the design intent of the engineering plans with the following exceptions:

- The storm sewer between structures L15 and L16 is laid at just 0.08% and may require more frequent cleaning.
- The storm sewer between structures B10 and B16 is laid at just 0.04% and may require more frequent cleaning.
- The sanitary manhole rims have all been set lower than design grade and have been paved over. These should be raised prior to placing the final asphalt surface course.
- The 15-inch sanitary sewer between manholes 3 and 4 has been laid at 0.09% and may require more frequent cleaning.

This statement and the record information shown constitute neither a warranty, expressed or implied, as to the existence, location, or quality of the improvements installed within this PROJECT, nor compliance with the PROJECT specifications, or any other matter that was part of the work or within the control of the CONTRACTOR.

Dated this 27th day of April, 2007.

JOHN W. STOLBERG
ILLINOIS LICENSED PROFESSIONAL ENGINEER
No. 021-044000
Expire 12-31-07

RECORD PLAN
AS OF 11-1-06
JMM
4-27-07

INTECH CONSULTANTS, INC. 5413 WALNUT AVE. DOWNERS GROVE, ILL. ILLINOIS REGISTRATION No. 184-001040	ENGINEERS SURVEYORS	WISEMAN-HUGHES ENTERPRISES 975 EAST 22nd STREET WHEATON, ILLINOIS	RESTON PONDS UNIT 3 SYCAMORE, ILLINOIS	PLAN & PROFILE NOTTINGHAM ROAD Sta. 0+00.00 TO Sta. 11+50.00	2/02/08 5 12/30/08 4 10/19/05 3 9/19/05 2 5/16/05 1	PER CITY REVIEW PER CITY REVIEW NO REVISIONS ON THIS SHEET NO REVISIONS ON THIS SHEET SERVICE LOCATIONS	DCK DCK DCK DCK DCK	DRAWN DCK DCK DESIGNED BY	SCALE HORIZ. 1" = 50' VERT. 1" = 5' DATE 12/15/03	SHEET 15 OF 24 PROJECT NO. 2001.029-3
					JWS/WB	JWS/WB				

